

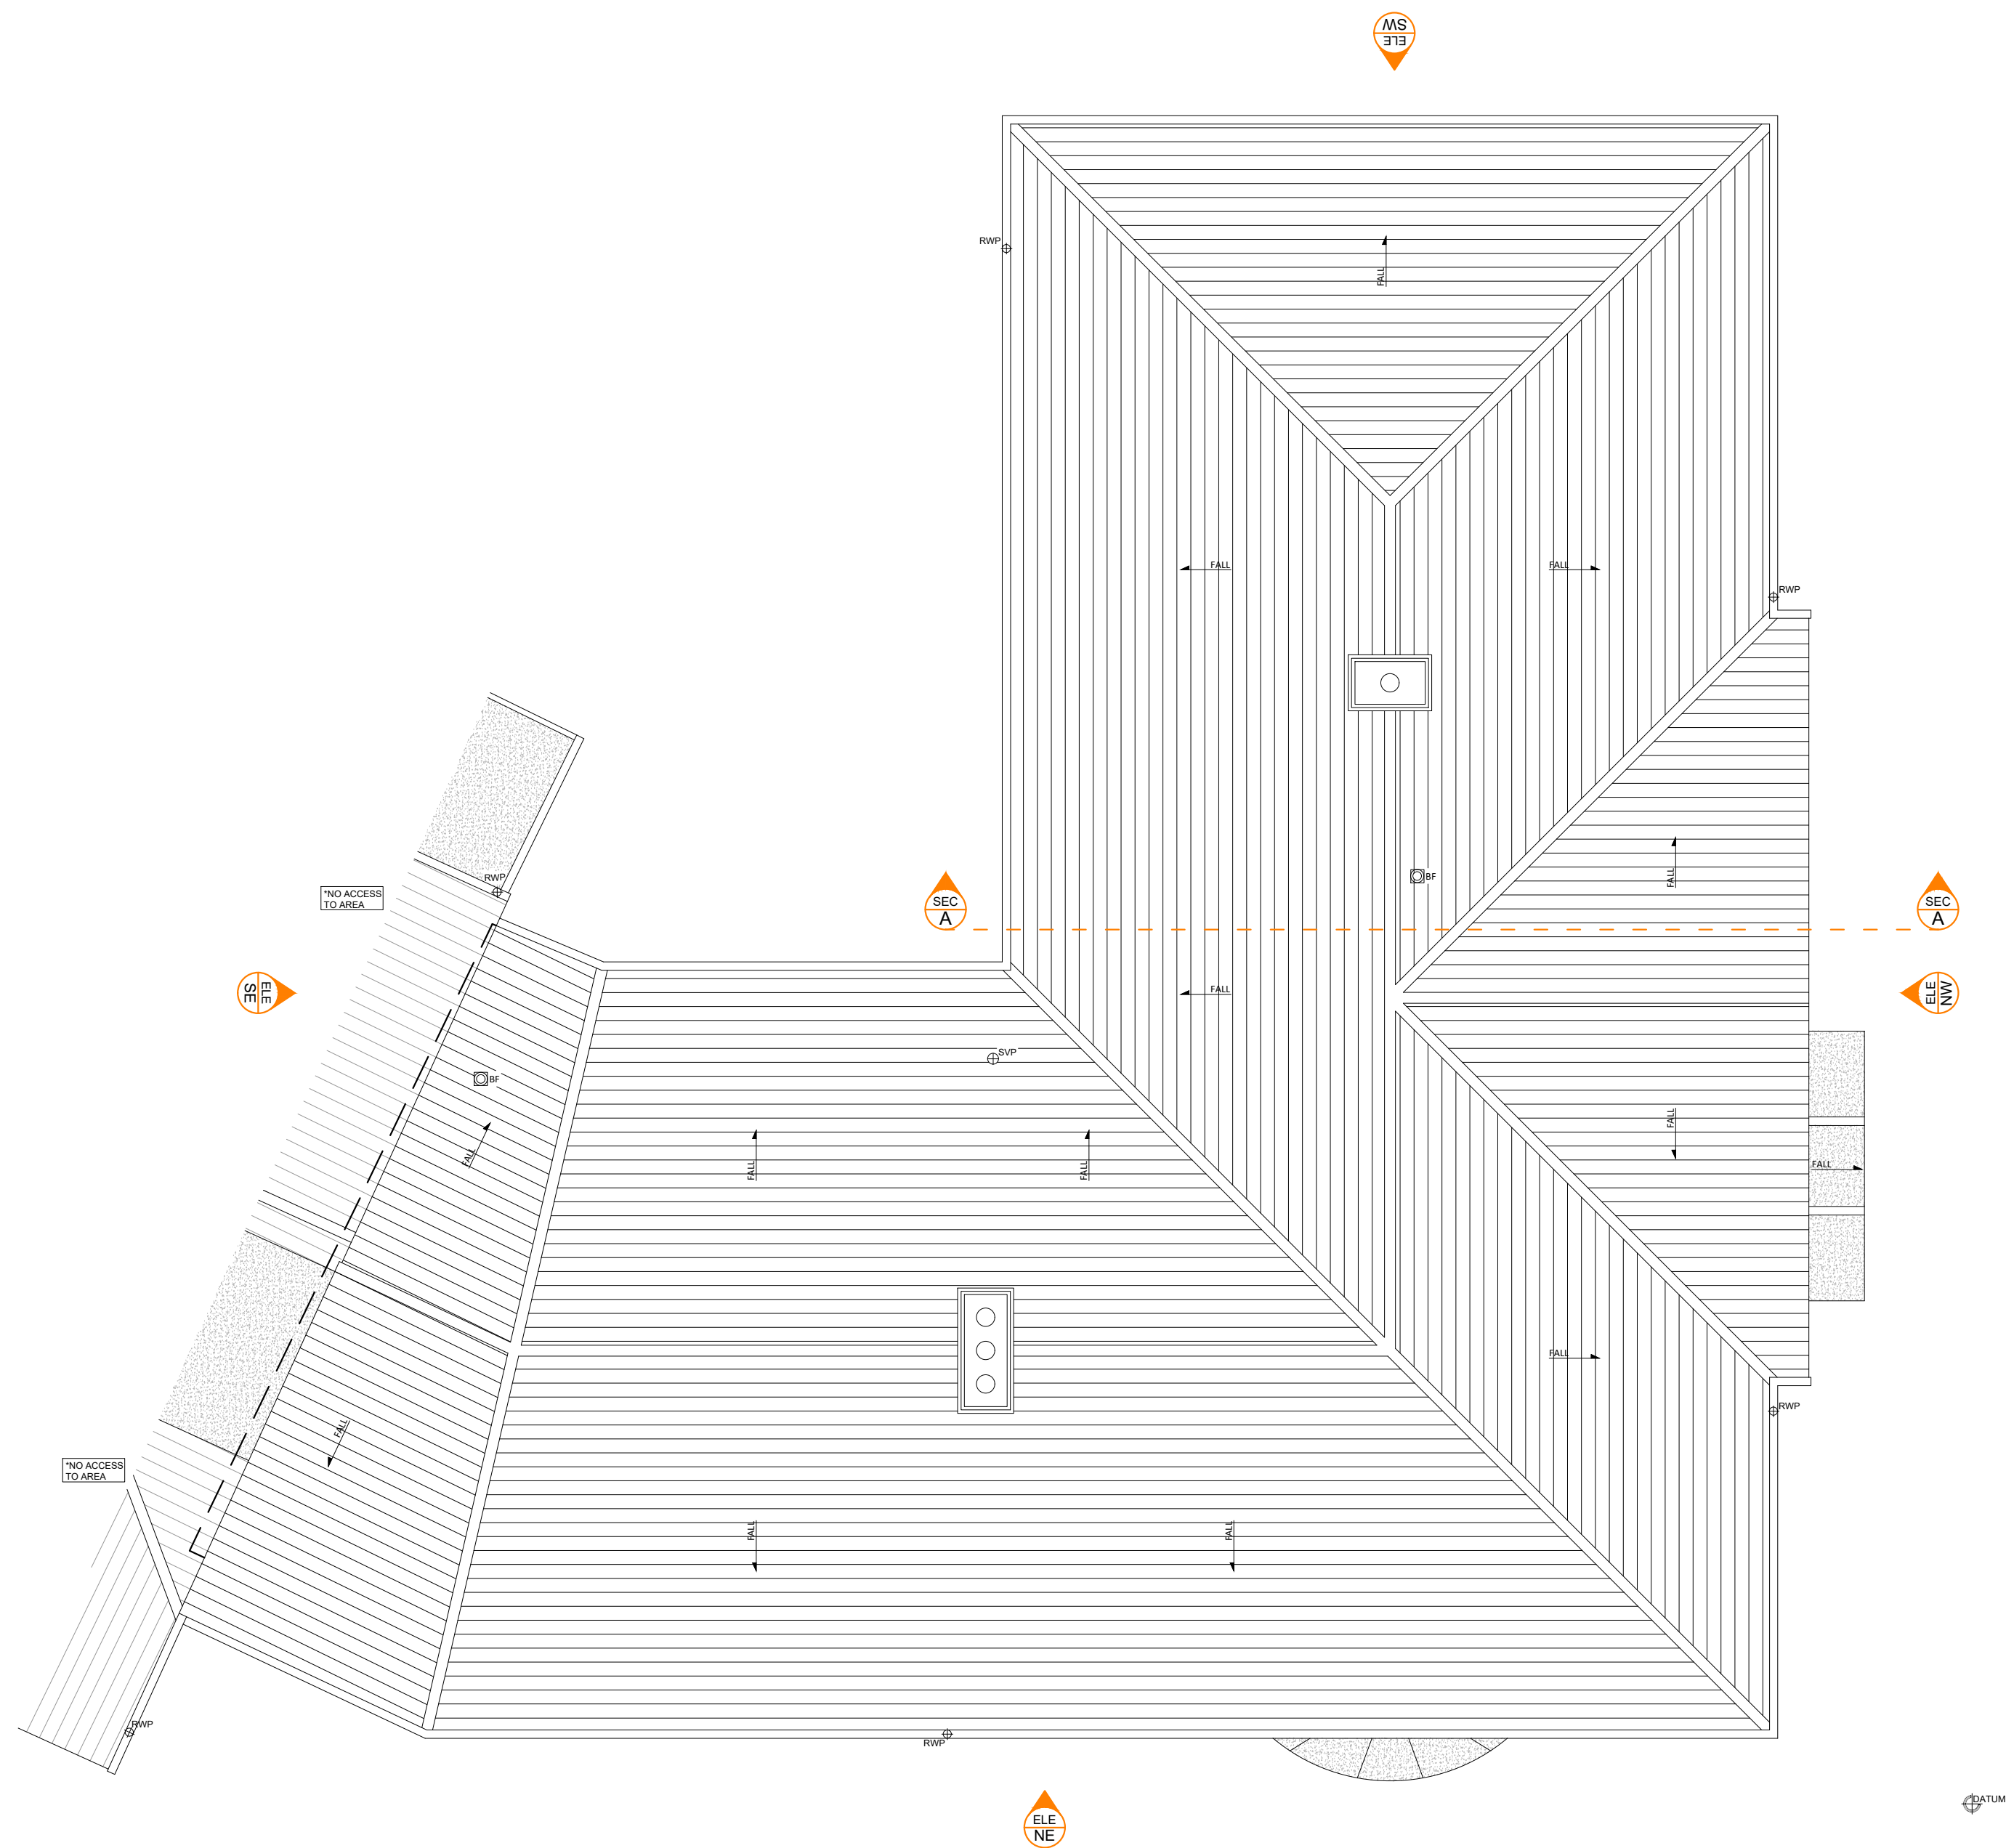


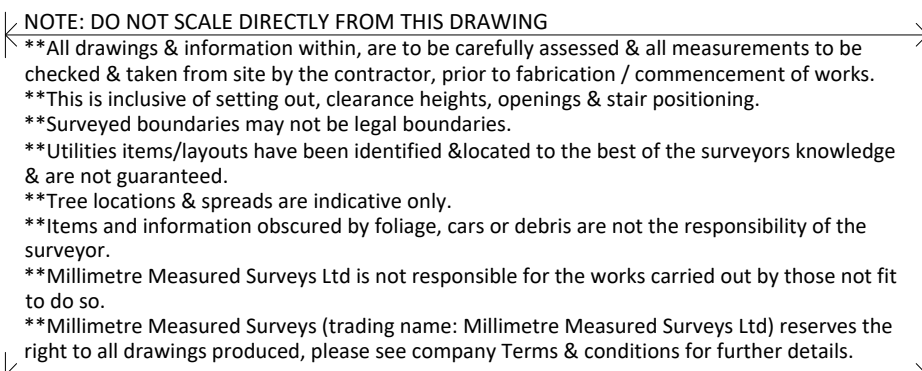

: AS EXISTING ROOF PLAN 1:50 @ A1

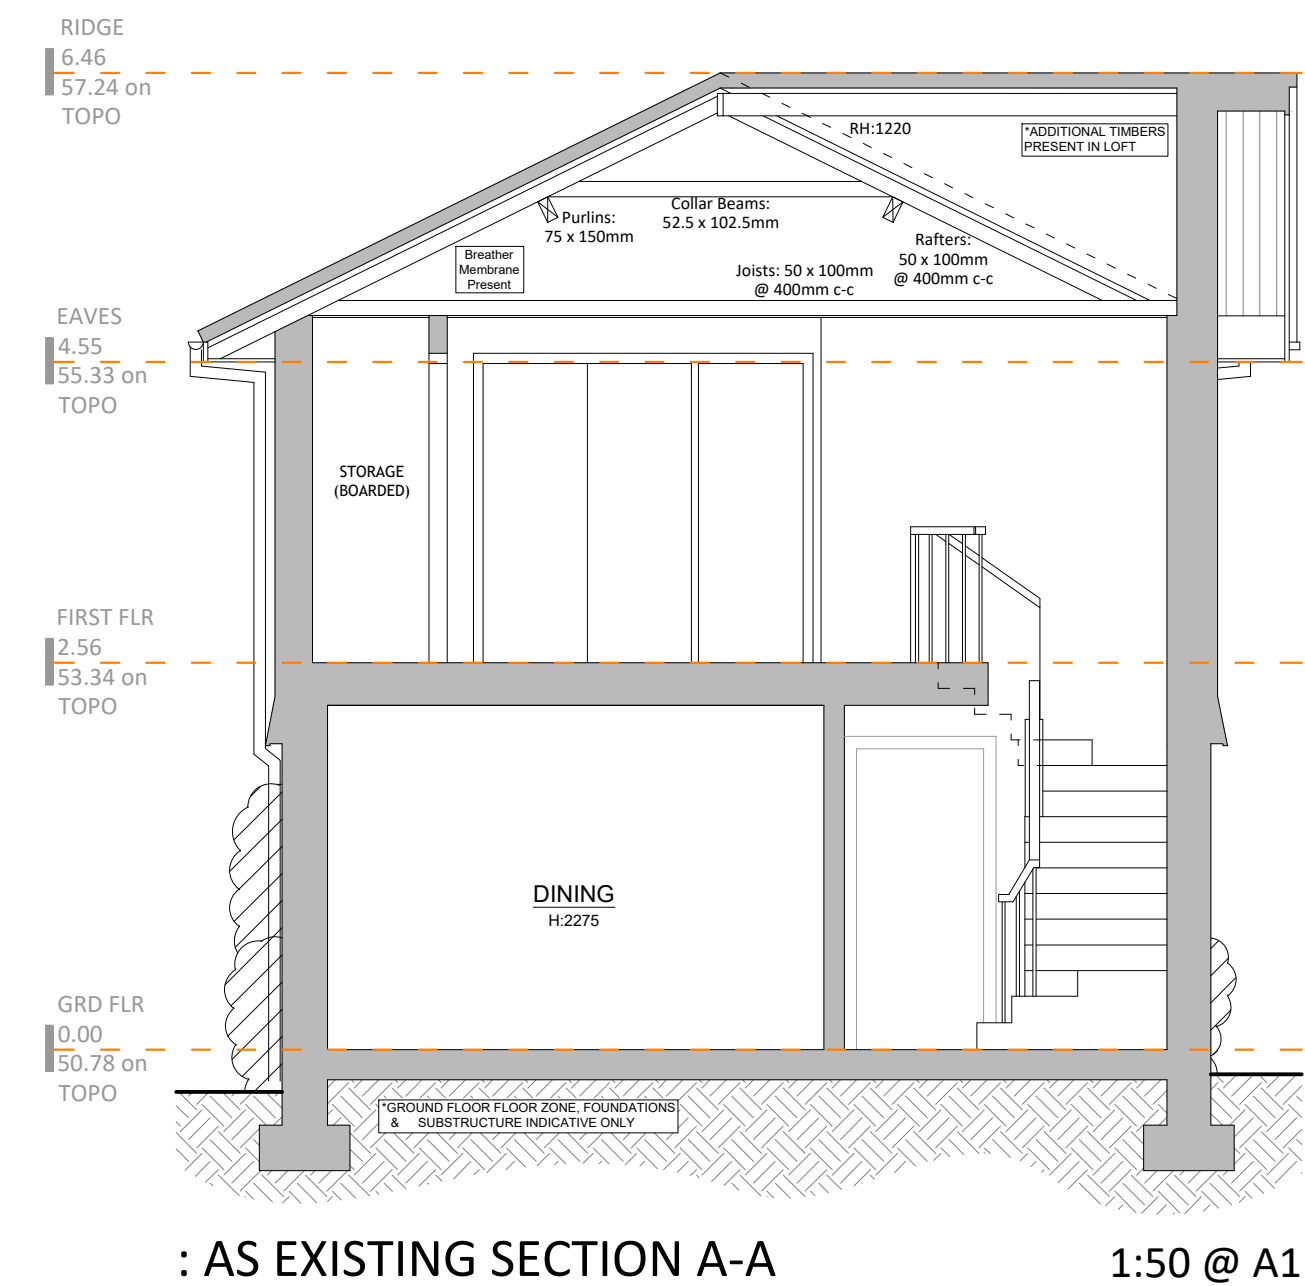

: AS EXISTING SECTION A-A 1:50 @ A1

MMS: DRAFTING KEY

TH10 →	THRESHOLD		FIRST FLOOR JOISTS		GAS	GAS METER
ST10 →	STEP				ELE	ELECTRICITY METER
HC2800	CEILING HEIGHT OR SPOT HEIGHT		ROOF FALL DIRECTION		CONSUMER UNIT	CONSUMER UNIT
CH2800	CHOOOR HEIGHT		RAINWATER PIPE		RADIATOR	
C200	WINDOW CLL & B&E HEIGHT	OP	DRAIN PIPE		HTR	HEATED TOWEL RAIL
C200	H1000	GULLEY	VERICAL DETECTOR			
R180	STAIR SPECIFICATIONS	SOIL VENTILATION PIPE	SMOKE DETECTOR		SD	SMOKE DETECTOR
R180	STAIRS, REIGERS, GOINGS	STUR STACK	HEAT DETECTOR			
	WASHING MACHINE/ DISHWASHER/TUMBLE DRYER	EXTERNAL PAT	KITCHEN VENT. EXTRACT		KV	KITCHEN VENT. EXTRACT
		INSPECTION CHAMBER & INVERT LEVEL	BATHROOM VENT. EXTRACT			BV
	FRIDGE FREEZER		BOILER			BP
					UTILITY ROOM VENT. FLUE	UTILITY ROOM VENT. FLUE
						TUMBLER DRYER VENT.

REV: DATE: NOTE:

PROJECT NO: 2232NPC

DRAWING NO: EX03 DRAWN BY: MMS

SCALE: 1:50 @ A1 **DATE:** 20.11.22

CLIENT: ALECIA RIDOUT

PROJECT : 4 NOSTEL PRIORY COTTAGES, BALCOMBE

TITLE : AS EXISTING ROOF PLAN & SECTION A-A



EMAIL: info@millimetresurveys.co.uk
WEB: www.millimetresurveys.co.uk
TEL: 07740351702

