


117880m.N  
117870m.N  
117860m.N  
117850m.N  
117840m.N  
117830m.N  
117820m.N  
117810m.N  
117800m.N  
117790m.N  
117780m.N


| REV.# | DATE | NAME | NOTES |
|-------|------|------|-------|
|       |      |      |       |
|       |      |      |       |
|       |      |      |       |
|       |      |      |       |
|       |      |      |       |
|       |      |      |       |
|       |      |      |       |

Notes:  
Do not scale this drawing.  
All levels and dimensions are to be checked on site.  
This drawing is to be read in conjunction with all relevant consultants drawings and specifications, together with safety plan requirements.  
Copyright: This drawing must not be copied, amended nor reproduced without the prior written agreement.

SPORTS FIELD

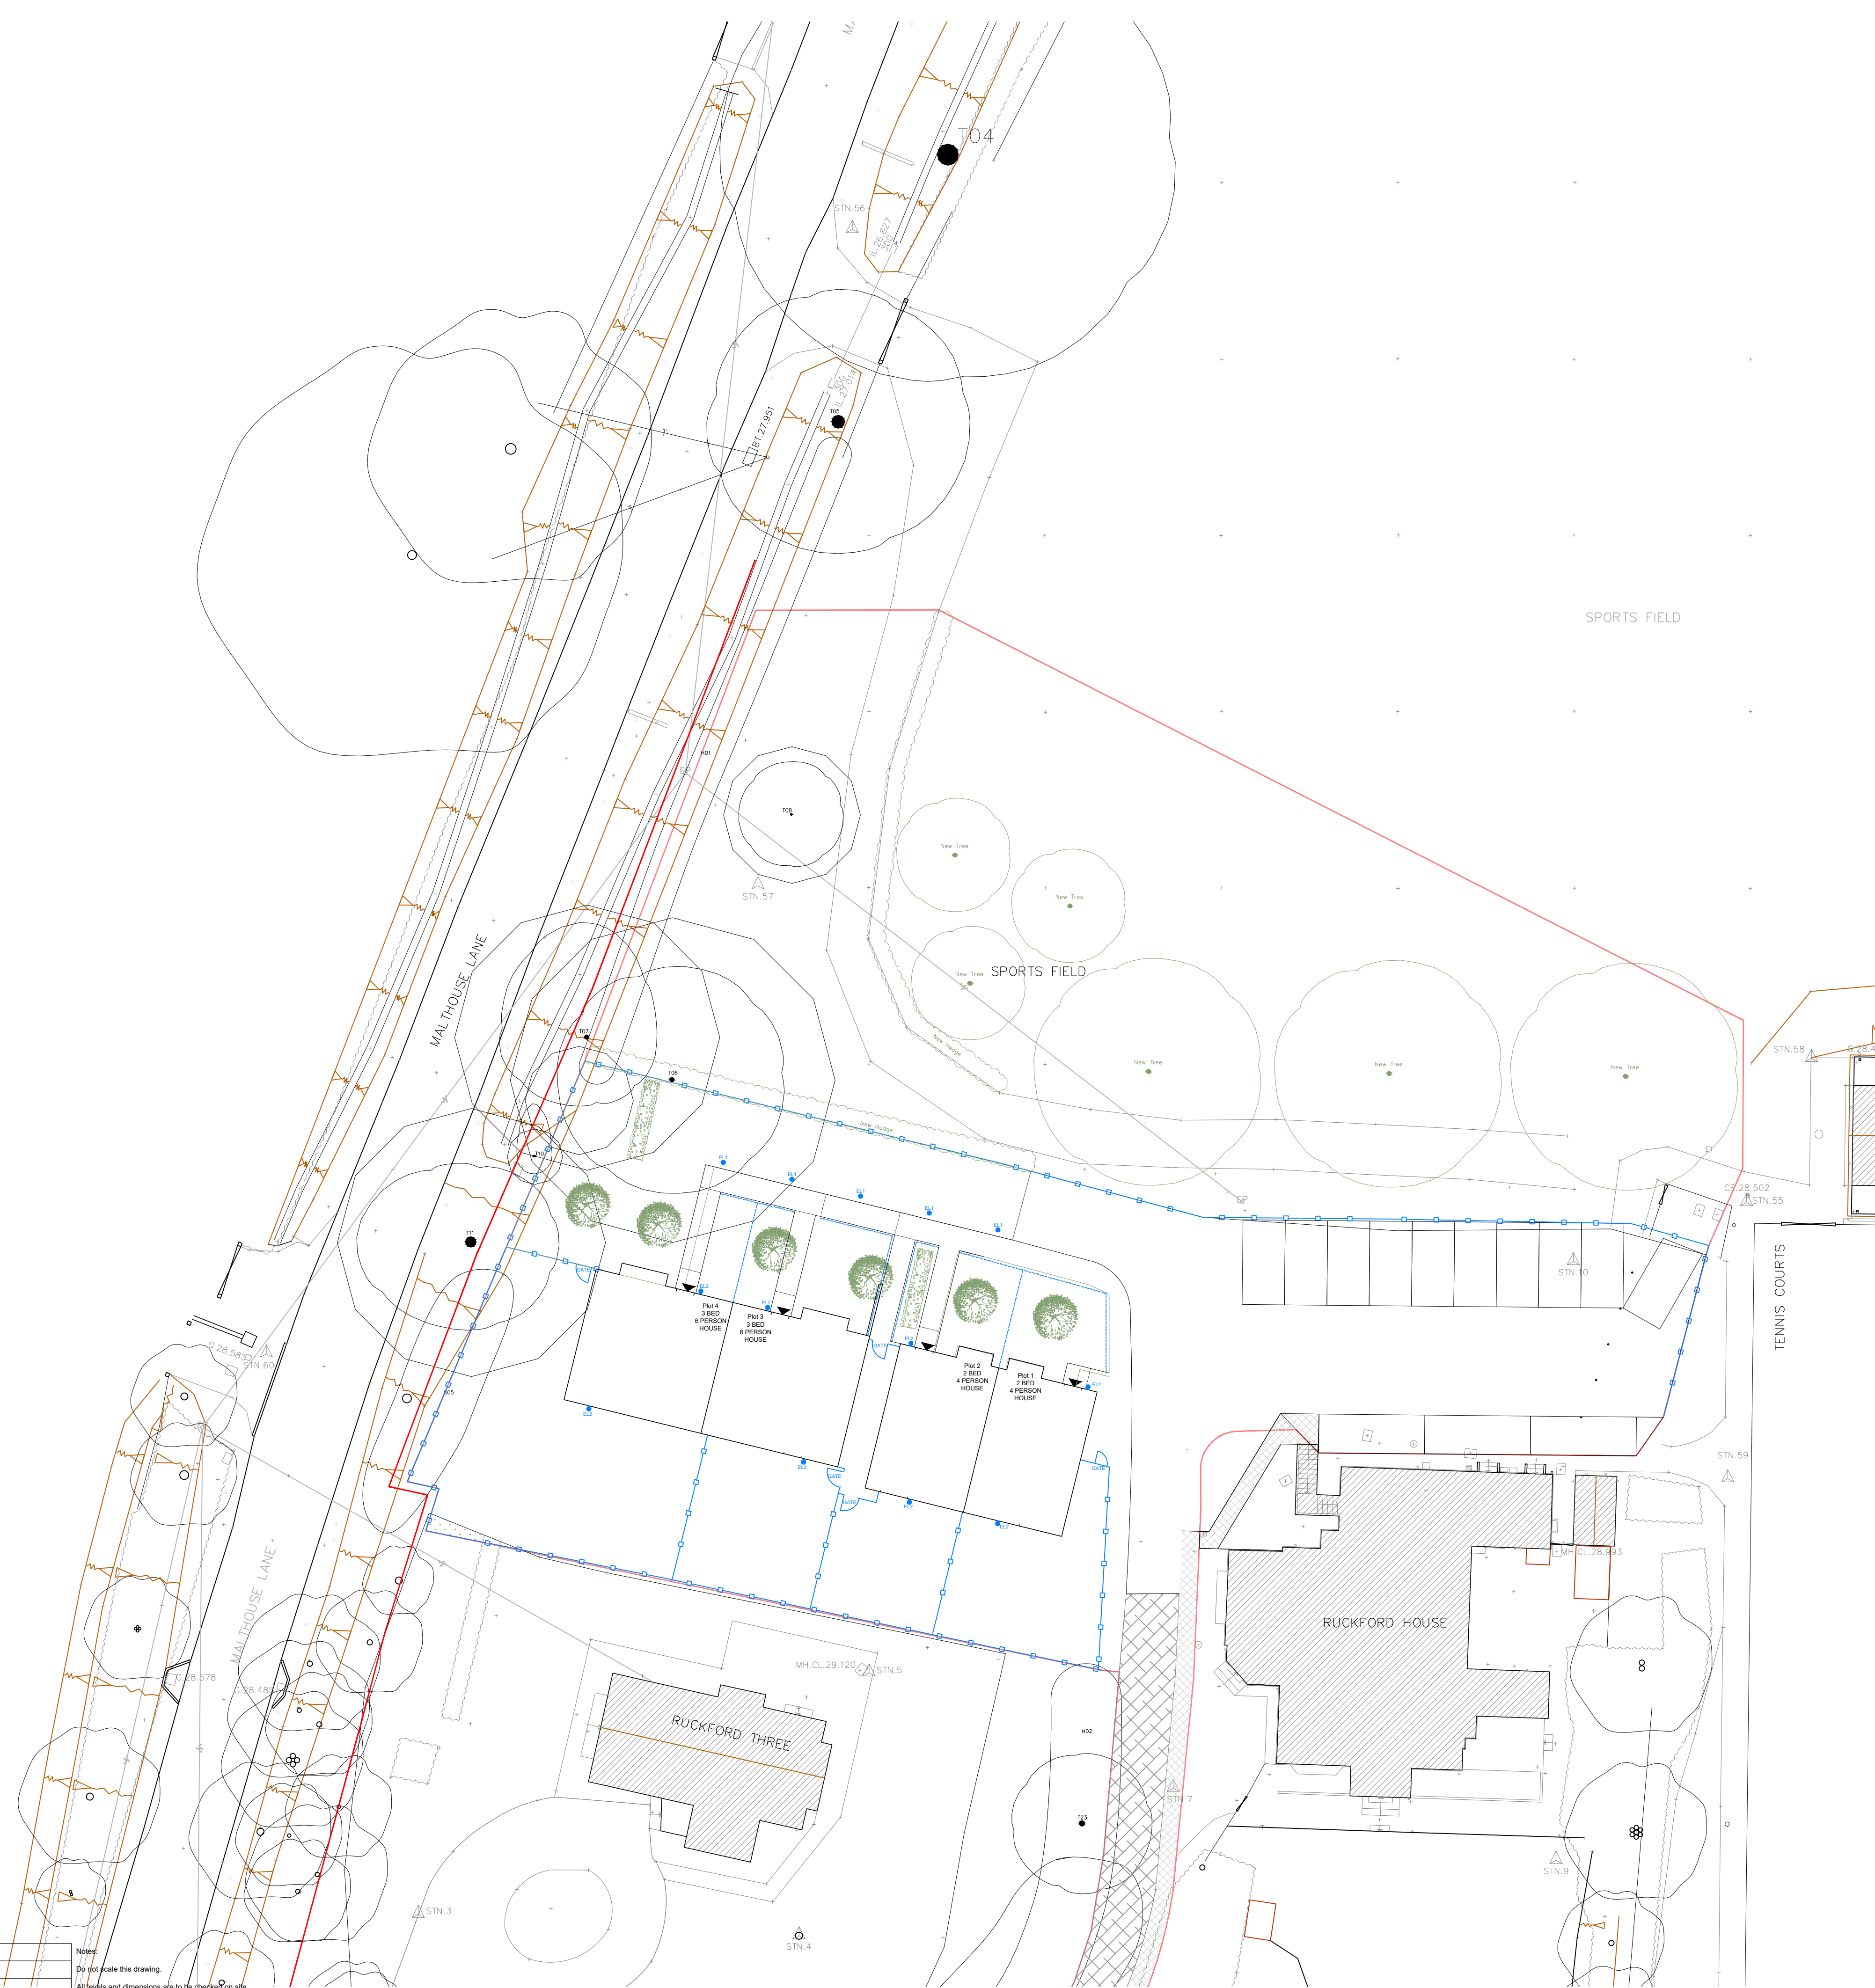

- KEY
- Proposed level
  - Existing level
  - Bin Fence
  - 500mm Timber fence rail
  - Highways boundary
  - Site boundary
  - EL1 — KSR Lighting Viella KSR1903 low-level bollard; 8.5W LED, 3000K, 75 mm, 28" downward beam, anthracite finish with bronze inlay, IP64, Class I; 250 mm high x 100 mm wide x 70 mm deep.
  - EL2 — External down-only wall light with integral PIR, mounted at 1.8 m above finished entrance level, at the front entrance and rear French doors, as shown. Fitting to be downward-directed with no upward light spill. PIR-controlled only with dusk-to-dawn operation. PIR time-out, wattage, lumen output, CCT, finish, IP rating.

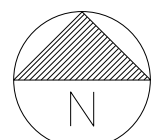

**BUILDING SOLUTIONS CONSULTANTS LTD.**

23 Trian road, Hove, BN3 5QR. Tel: 07834611763

|         |                                                |                  |                         |
|---------|------------------------------------------------|------------------|-------------------------|
| PROJECT | Ruckford Staff Housing, Hurstpierpoint College |                  |                         |
| DRAWING | Fencing and Lighting Layout                    |                  |                         |
| STAGE   | External Lighting and Boundary Treatments Plan | JOB NO. : 719    | DATE : 01/08/2026       |
| DWG NO. | AL225                                          | SCALE : 1:200@A1 | REVISION : - DRAWN : DB |

Do not scale. Use figured dimensions only. Check dimensions on site. Notify BSC of any discrepancies. Copyright BSC Ltd.