


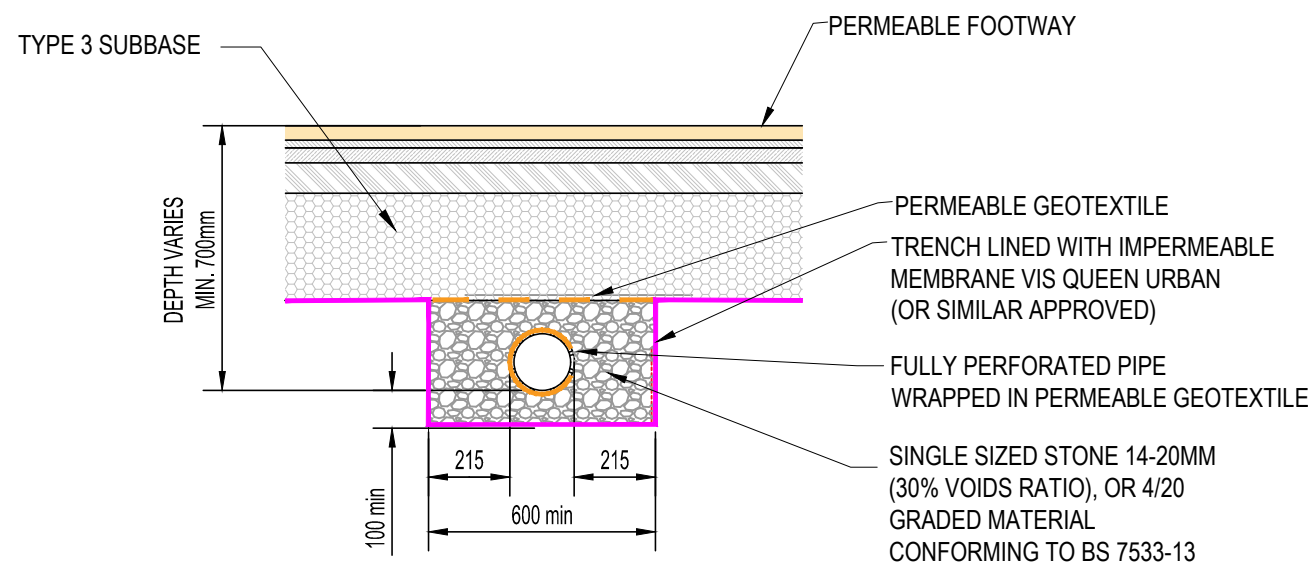
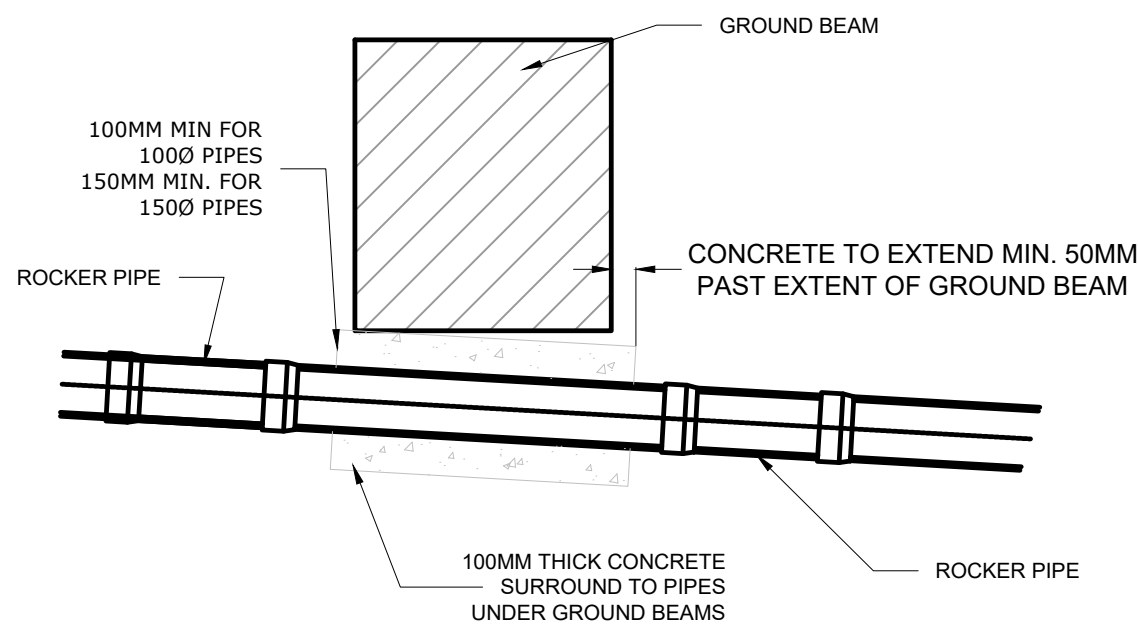


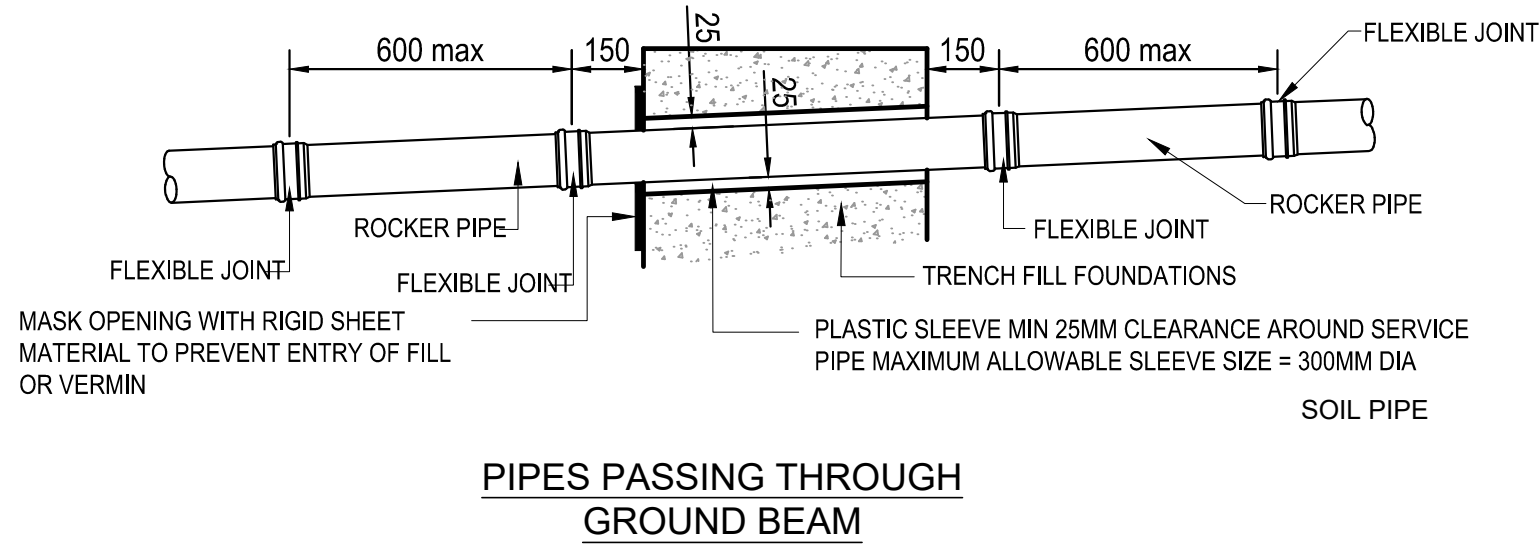


PERFORATED PIPE/ FILTER DRAIN UNDER PERMEABLE FOOTWAY

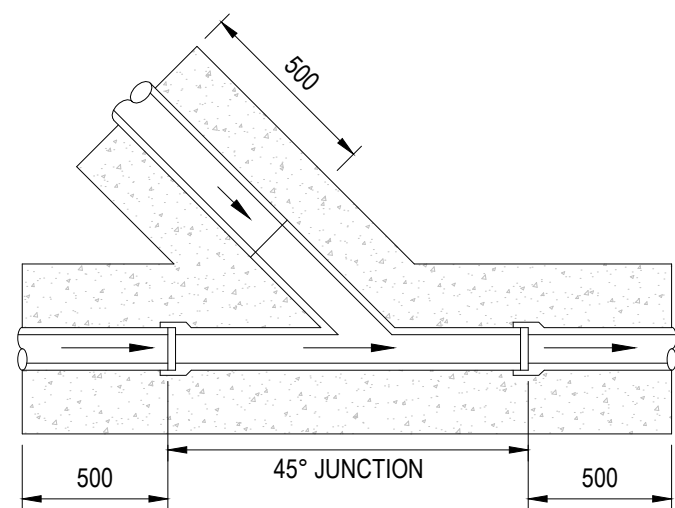


TYPICAL SADDLE CONNECTION

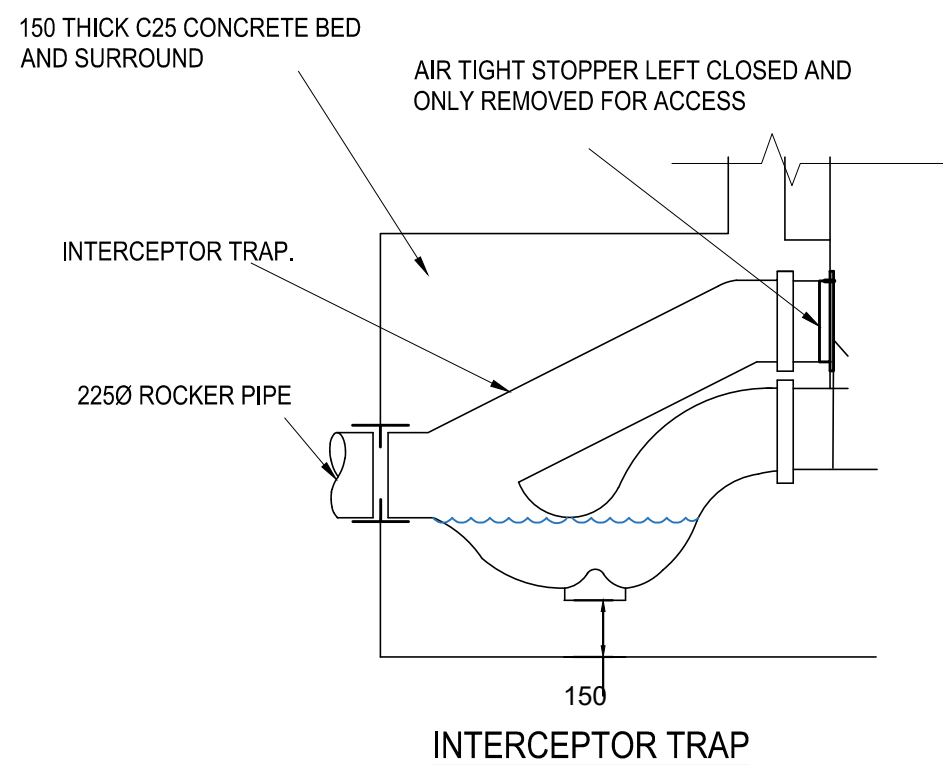


INTERCEPTOR TRAP

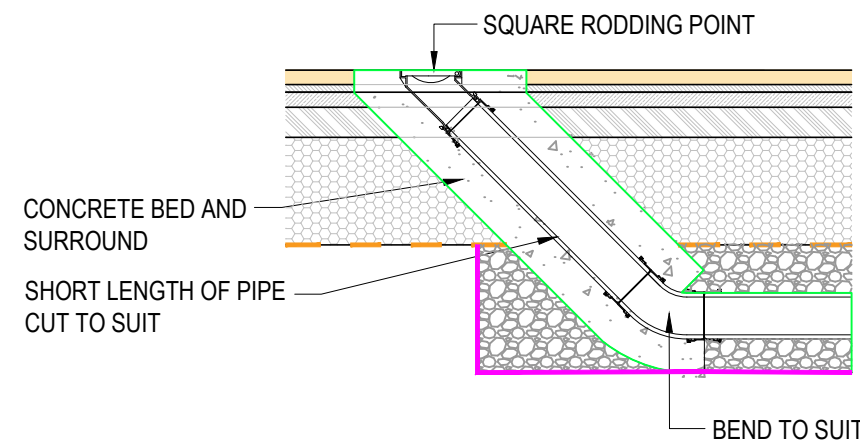


RODDING POINT DETAIL (RE)

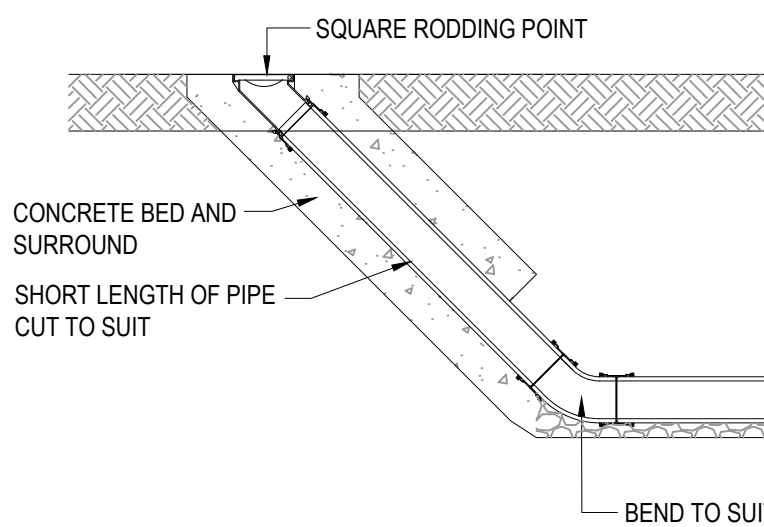


RODDING POINT DETAIL (RE)

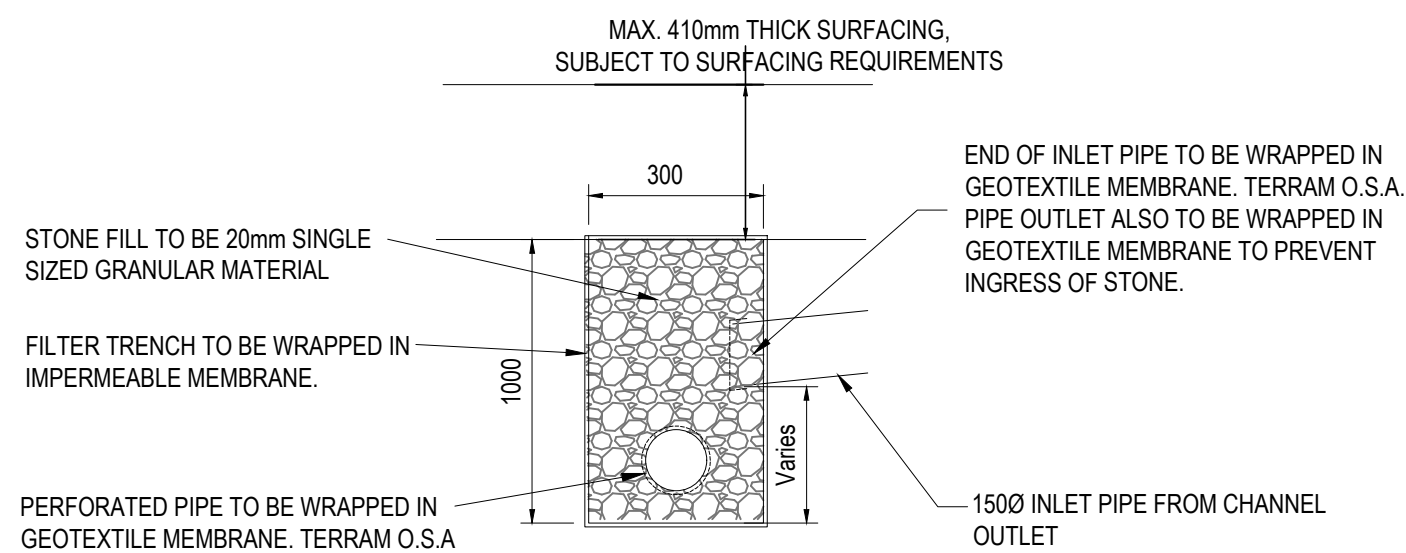

TYPICAL FILTER STRIP DETAIL inc. INLET CONNECTION

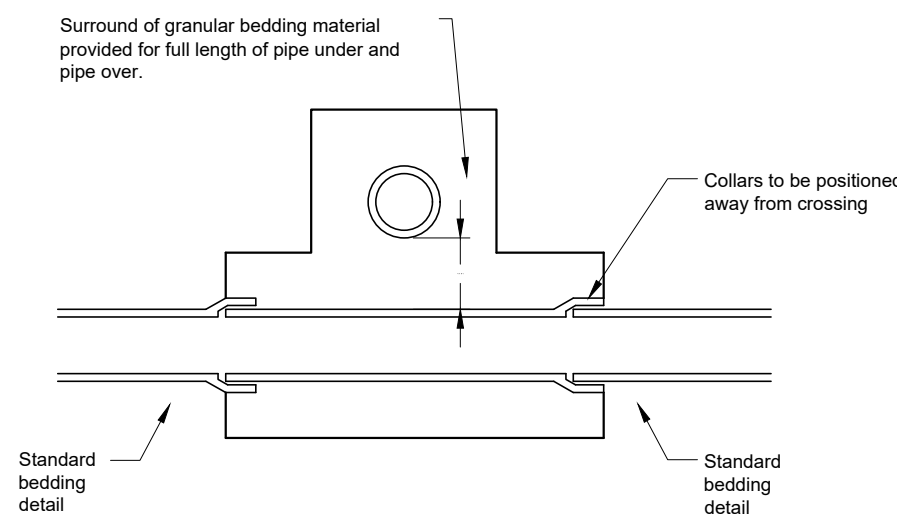

PIPE CROSSINGS DETAIL

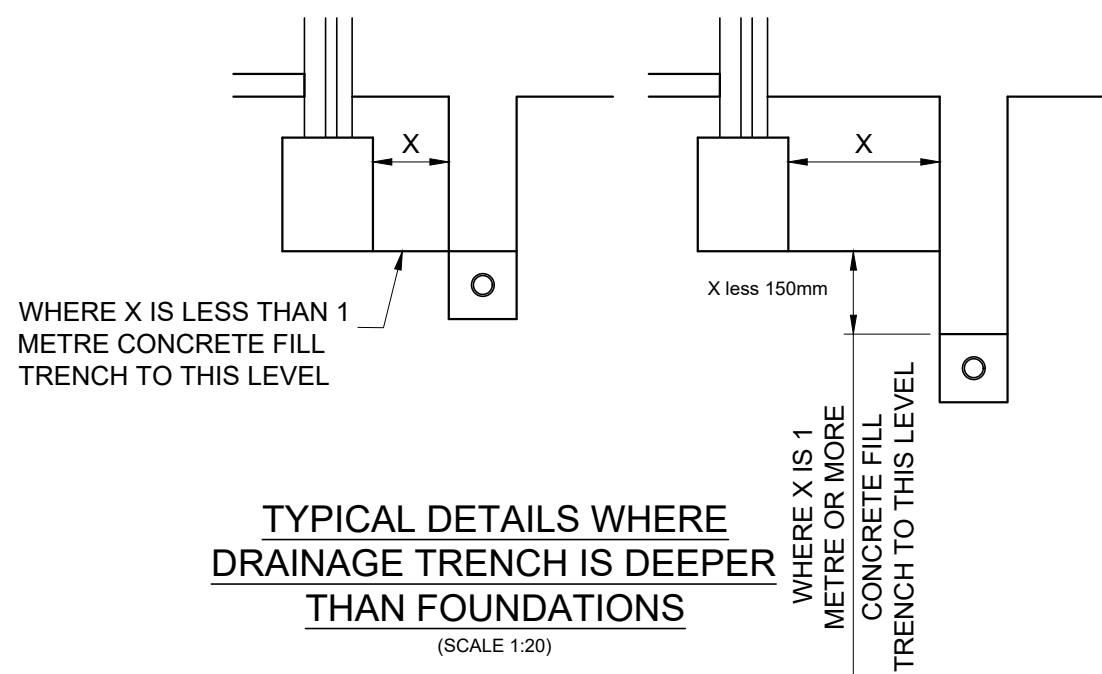

TYPICAL DETAILS WHERE DRAINAGE TRENCH IS DEEPER THAN FOUNDATIONS (SCALE 1:20)

GENERAL NOTES:

- THIS DRAWING IS TO BE READ IN CONJUNCTION WITH ALL RELEVANT ARCHITECTS AND ENGINEERS DRAWINGS AND SPECIFICATIONS.
- DO NOT SCALE THIS DRAWING. ANY AMBIGUITIES, OMISSIONS AND ERRORS ON DRAWINGS SHALL BE BROUGHT TO THE ENGINEERS ATTENTION IMMEDIATELY. ALL DIMENSIONS MUST BE CHECKED / VERIFIED ON SITE.
- ALL DIMENSIONS ARE IN MILLIMETRES UNLESS NOTED OTHERWISE.
- REFER TO DRAINAGE LAYOUT 084783-CUR-MD-XX-D-C-92500 FOR THE LOCATION OF THE ATTENUATION TANK.
- FLOW CONTROL TO BE INSTALLED IN STRICT ACCORDANCE WITH THE MANUFACTURERS REQUIREMENTS, INSTRUCTIONS AND RECOMMENDATIONS.
- WHERE ALTERNATIVE FLOW CONTROL DEVICE IS PREFERRED, IT WILL BE SUBJECT TO REDESIGN TO CONFIRM WHETHER THE SYSTEM HAS CAPACITY.
- SURFACE WATER DRAINAGE CONNECTION SUBJECT TO S106 AGREEMENT WITH UNITED UTILITIES
- FOR FULL DRAINAGE NOTES REFER TO 076038-CUR-XX-00-DR-D-92020

P02	REFERENCES UPDATED	18/08/26	ATL	ATL
P01	STAGE 4 ISSUE	23/07/26	ATL	PB
Rev:	Description:	Date:	By:	Chkd:

Curtins
Merchant Exchange, 17-19 Whitworth Street West, Manchester, M1 5WG
0161 236 2394
manchester@curtins.com
www.curtins.com

Civils & Structures • Transport Planning • Environmental • Infrastructure • Geotechnical • Conservation & Heritage • Principal Designer
Birmingham • Bristol • Cambridge • Cardiff • Douglas • Dublin • Edinburgh • Glasgow • Kendal • Leeds • Liverpool • London • Manchester • Nottingham

Status:	SUITABLE FOR INFORMATION	S2
---------	--------------------------	----

Project:	HASSOCKS - RESIDENTIAL HOME
----------	-----------------------------

Orig Title:

DRAINAGE DETAILS
SHEET 3

Drawn By	Designed By	Checked By
ATL	ATL	PB
Date	23/07/26	Scales @ A1
		NTS

Project No - Originator - Function - Spatial - Form - Discipline - Number	Revision
076038 - CUR - XX - 00 - DR - D - 92012	P02