


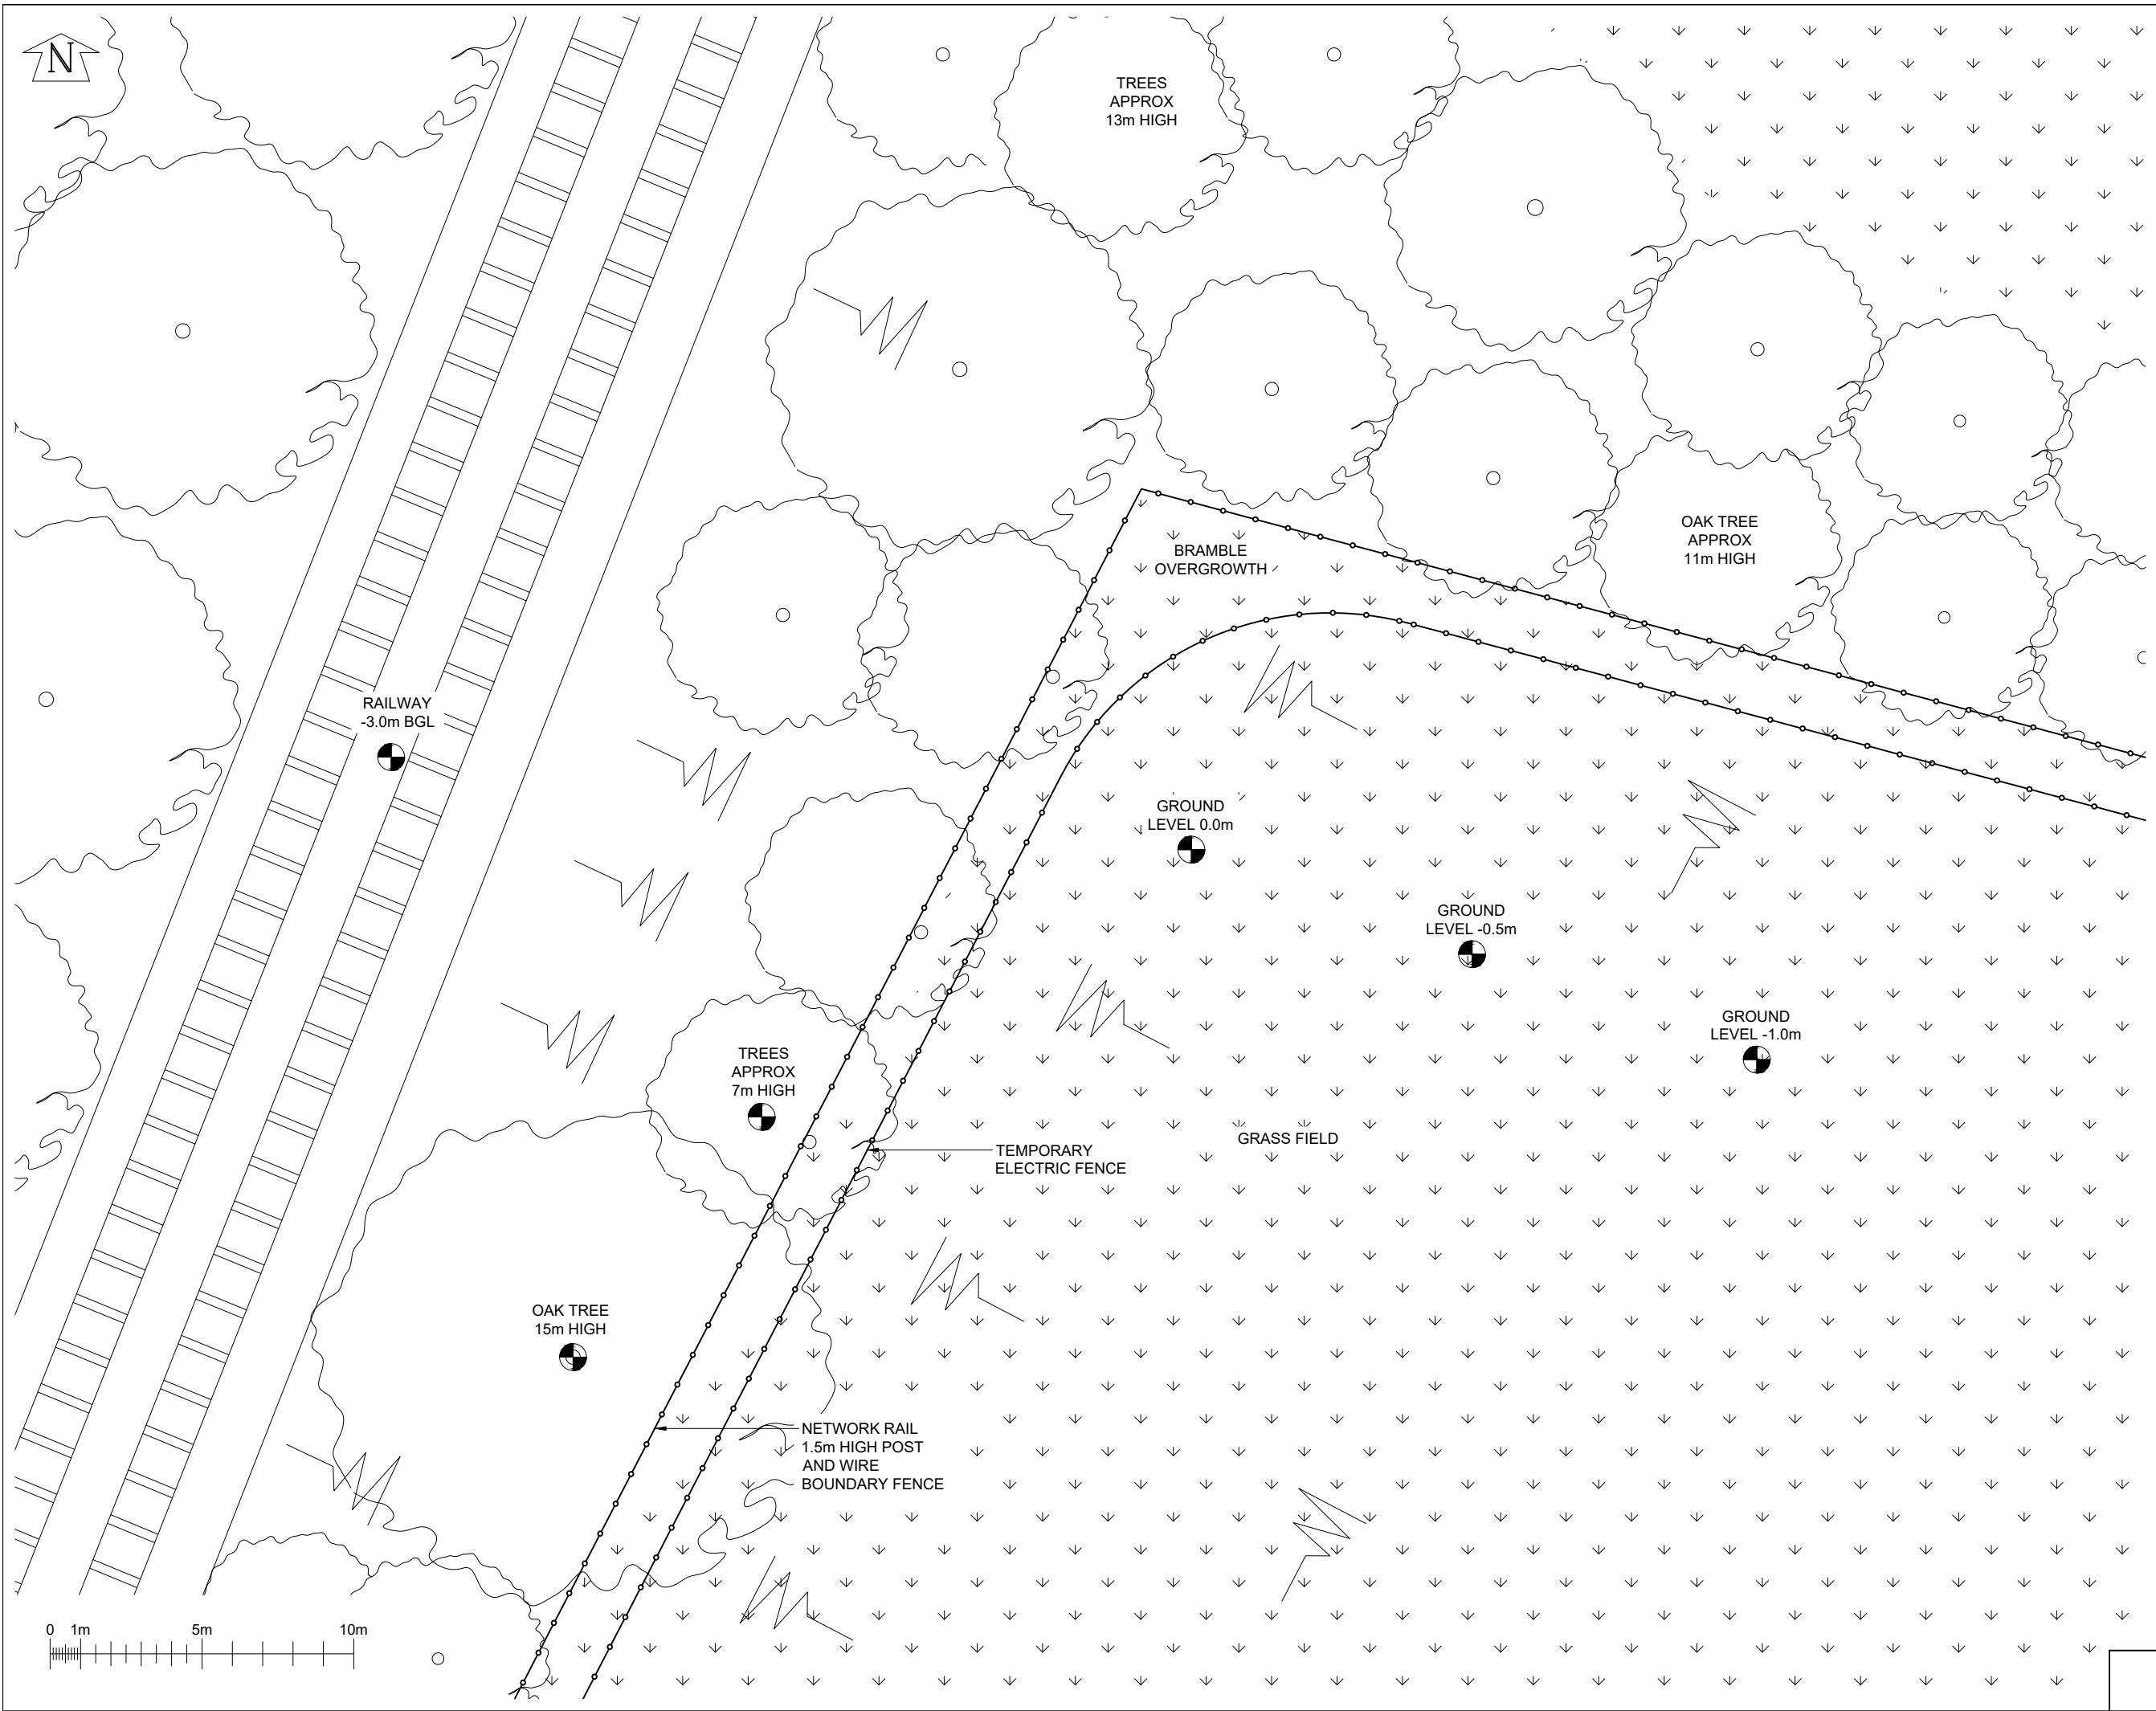

©2020 Cellnex
All rights reserved. No part of this publication may be reproduced, stored in a retrieval system or transmitted in any form or by any means (Electronic, Mechanical, Photocopying, Recording or otherwise), without the prior written consent of the Company.

NOTES

UNDERGROUND SERVICES
UNDERGROUND SERVICES ARE INDICATIVE ONLY. POSITIONS SHOULD BE CONFIRMED ON SITE PRIOR TO ANY DEVELOPMENT

DRAINAGE
DUCTS
FEEDERS
FENCE PLAN
GAS
LIGHTNING PROTECTION - EARTHING

POWER
SERVICES UNKNOWN
TELECOMS
WATER

ACCESS ARRANGEMENTS

KEYS:-

ARQIVA GATE KEY
B KEY
C KEY
LEGGE KEY

SURVEY REQUIRED TO CONFIRM ACCESS KEYS FOR REMAINING ROOMS AND SITE ENTRANCE

CELL No.	S5_16D			
1.A			CIR	
1		06/03/23	KG	MK
ISS	REVISION	DATE	DRN	APP

cellnex
driving telecom connectivity

CELLNEX UK
R+, 4TH FLOOR, 2 BLA GRAVE STREET, READING, RG1 1AZ
Tel. 020 4526 8553

SITE No **S5-16d**
OCKLEY PARK
OCKLEY PARK, OCKLEY HILL
HASSOCKS
RH15 9HR

NGR **TQ 31170 17513**

OS GRID **531170, 117513**

TITLE
SITE PLAN
EXISTING

SCALE **1:200**

DRAWN	KG	17/11/22
APPROVED	MK	06/03/23

DRG No. Sheet 1 of 1 Rev

S5-16d-00-000-MD001 **1.A**