


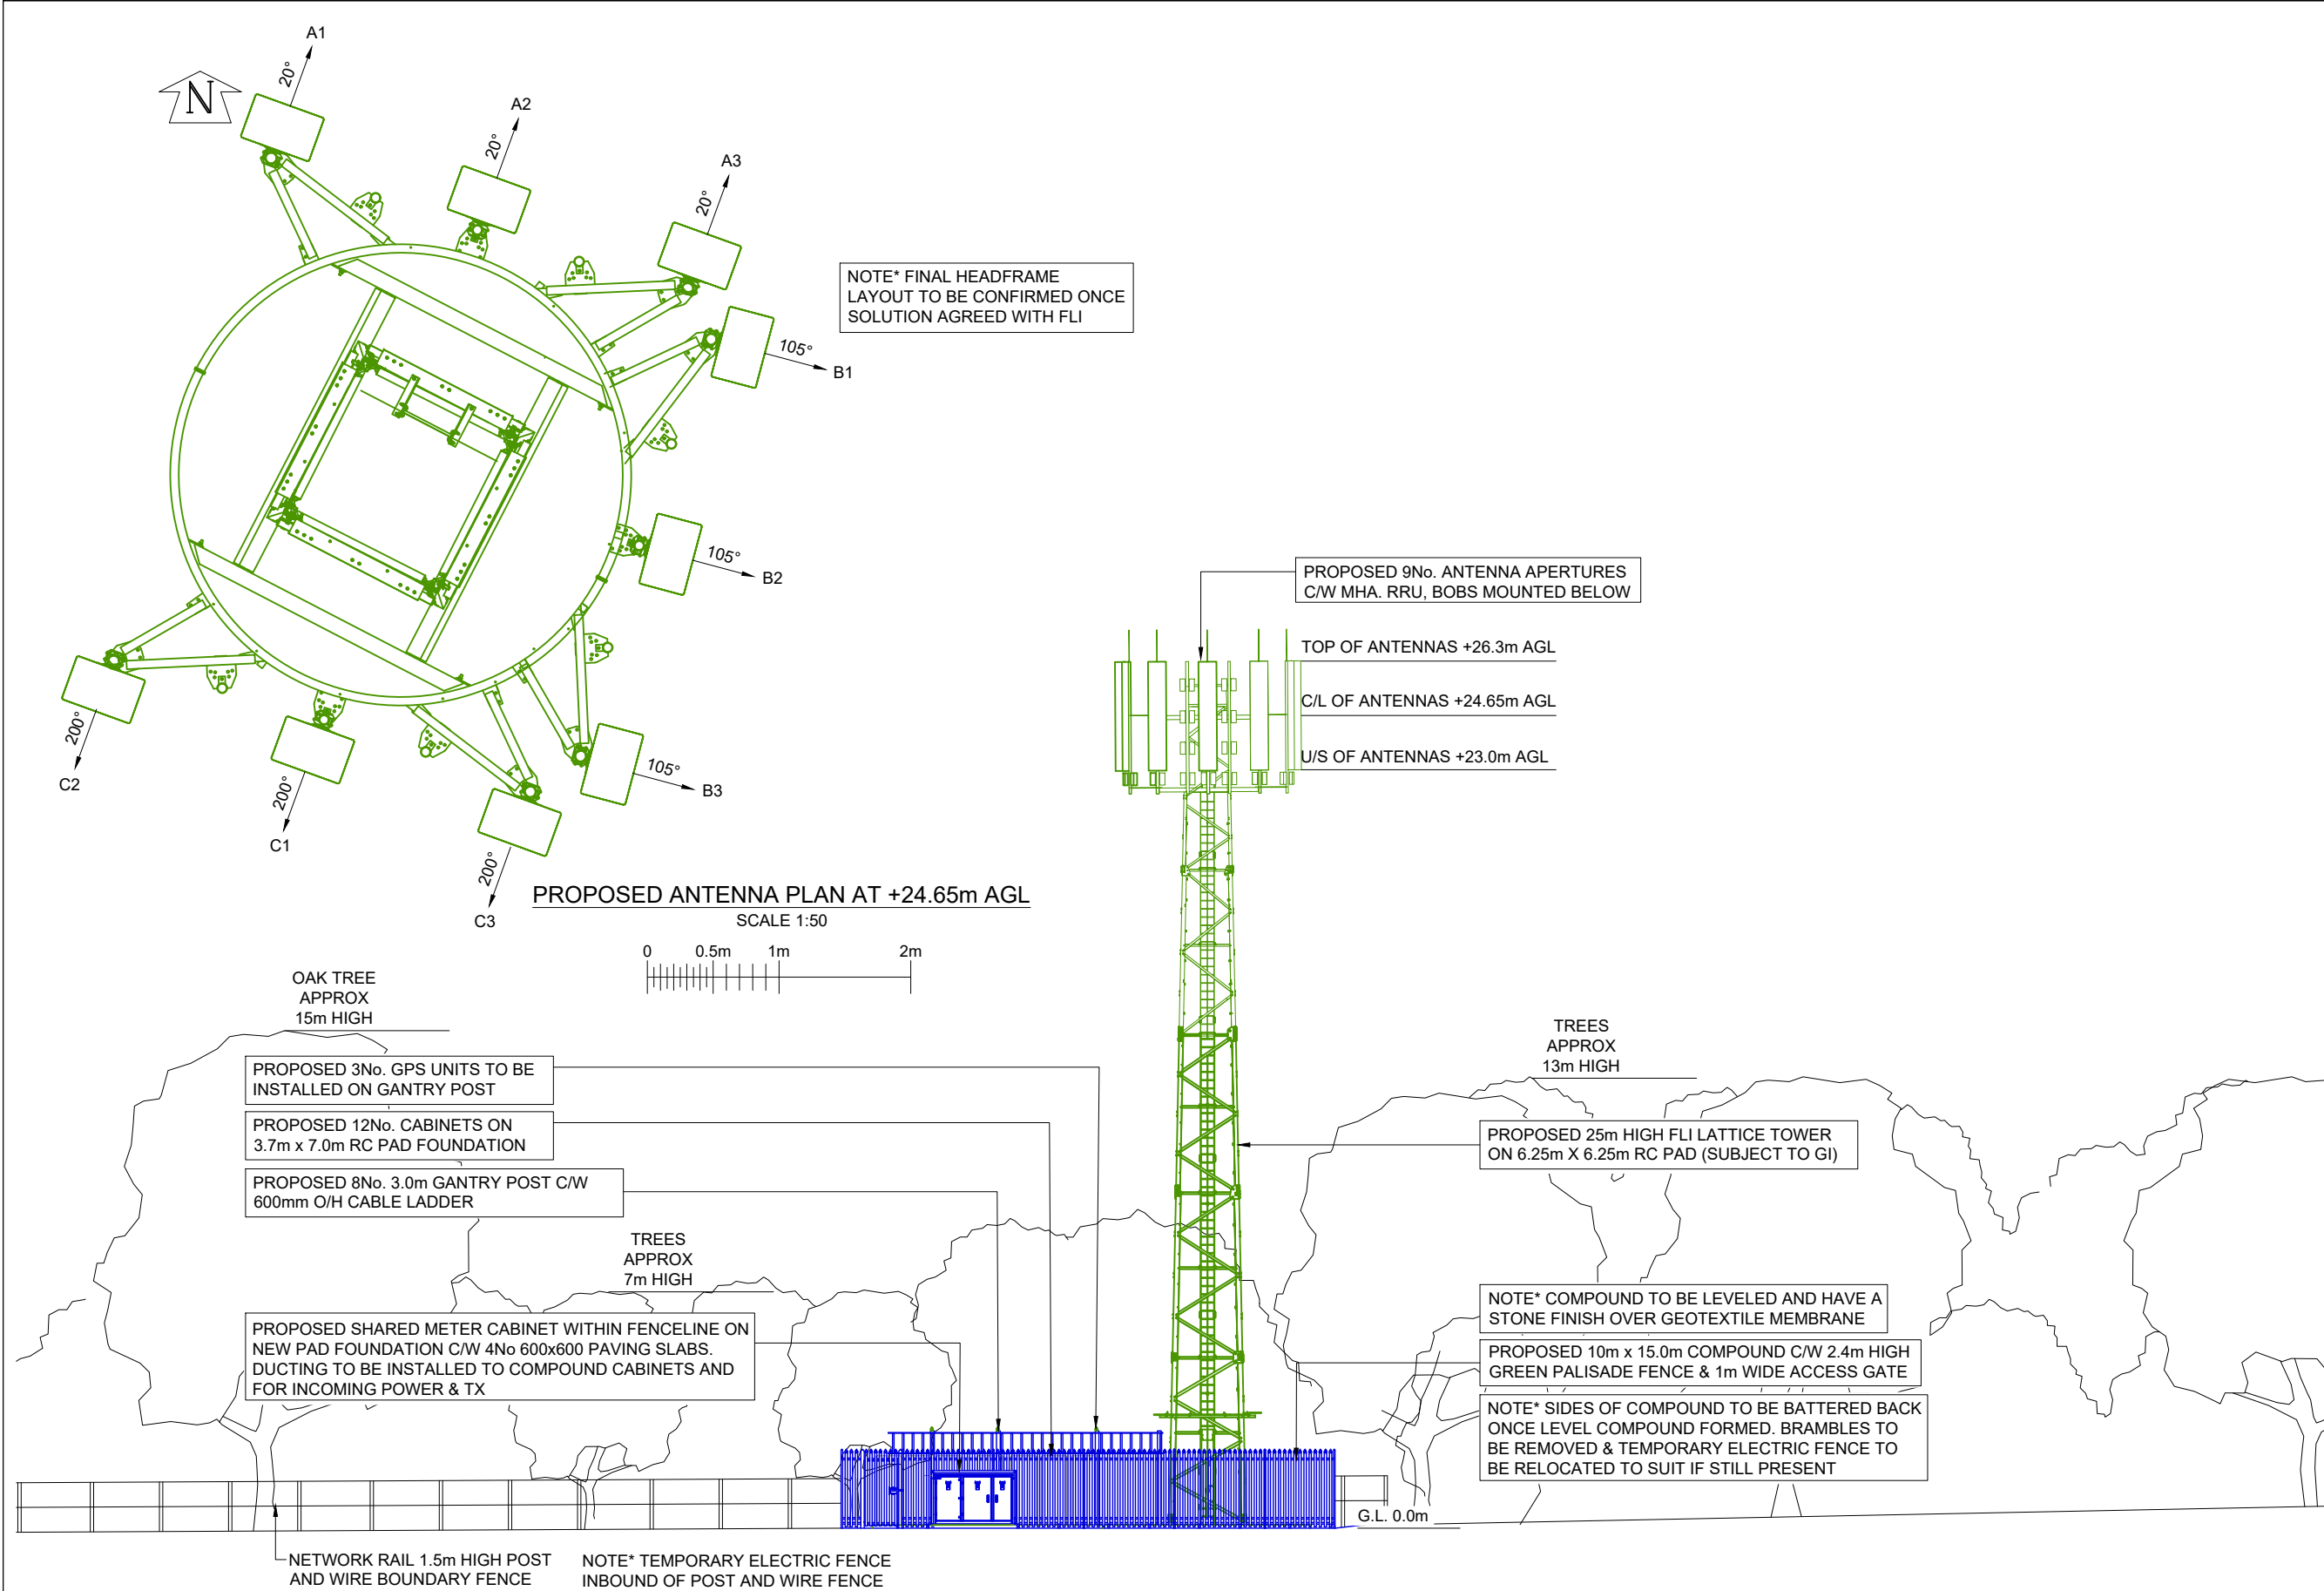

EQUIPMENT CABINET SCHEDULE							
ID No	EQUIPMENT	MANUFACTURER	DIMENSIONS (WxDxH) mm	COLOUR	LOCATION	STATUS	COMMENTS
CAB 1	PSU CABINET (x2)	TBC	770x770x2100	RAL 6009	PAD FOUNDATION	PROPOSED	-
CAB 2	TX CABINET (x2)	TBC	1500x600x1200	RAL 6009	PAD FOUNDATION	PROPOSED	
CAB 3	RADIO CABINET (x7)	TBC	770x770x2100	RAL 6009	PAD FOUNDATION	PROPOSED	
CAB 4	POWER & TX CAB (x1)	TBC	770x770x2100	RAL 6009	PAD FOUNDATION	PROPOSED	
CAB 5	SMC (x1)	TBC	1873x560x588	RAL 6009	PAD FOUNDATION	PROPOSED	

©2020 Cellnex
All rights reserved. No part of this publication may be reproduced, stored in a retrieval system or transmitted in any form or by any means (Electronic, Mechanical, Photocopying, Recording or otherwise), without the prior written consent of the Company.

NOTES

CELL No.	S5_16D
1.A	
1	06/03/23 KG MK
ISS	REVISION DATE DRN APP

cellnex
driving telecom connectivity

CELLNEX UK
R+, 4TH FLOOR, 2 BLA GRAVE STREET, READING, RG1 1AZ
Tel. 020 4526 8553

SITE No **S5-16d**
OCKLEY PARK
OCKLEY PARK, OCKLEY HILL
HASSOCKS
RH15 9HR

NGR **TQ 31170 17513**
OS GRID **531170, 117513**

TITLE
WEST ELEVATION
PROPOSED

SCALE **1:200 UNO**

DRAWN **KG** 17/11/22
APPROVED **MK** 06/03/23

DRG No. **S5-16d-00-003-MD001** Sheet 1 of 1 Rev **1.A**