


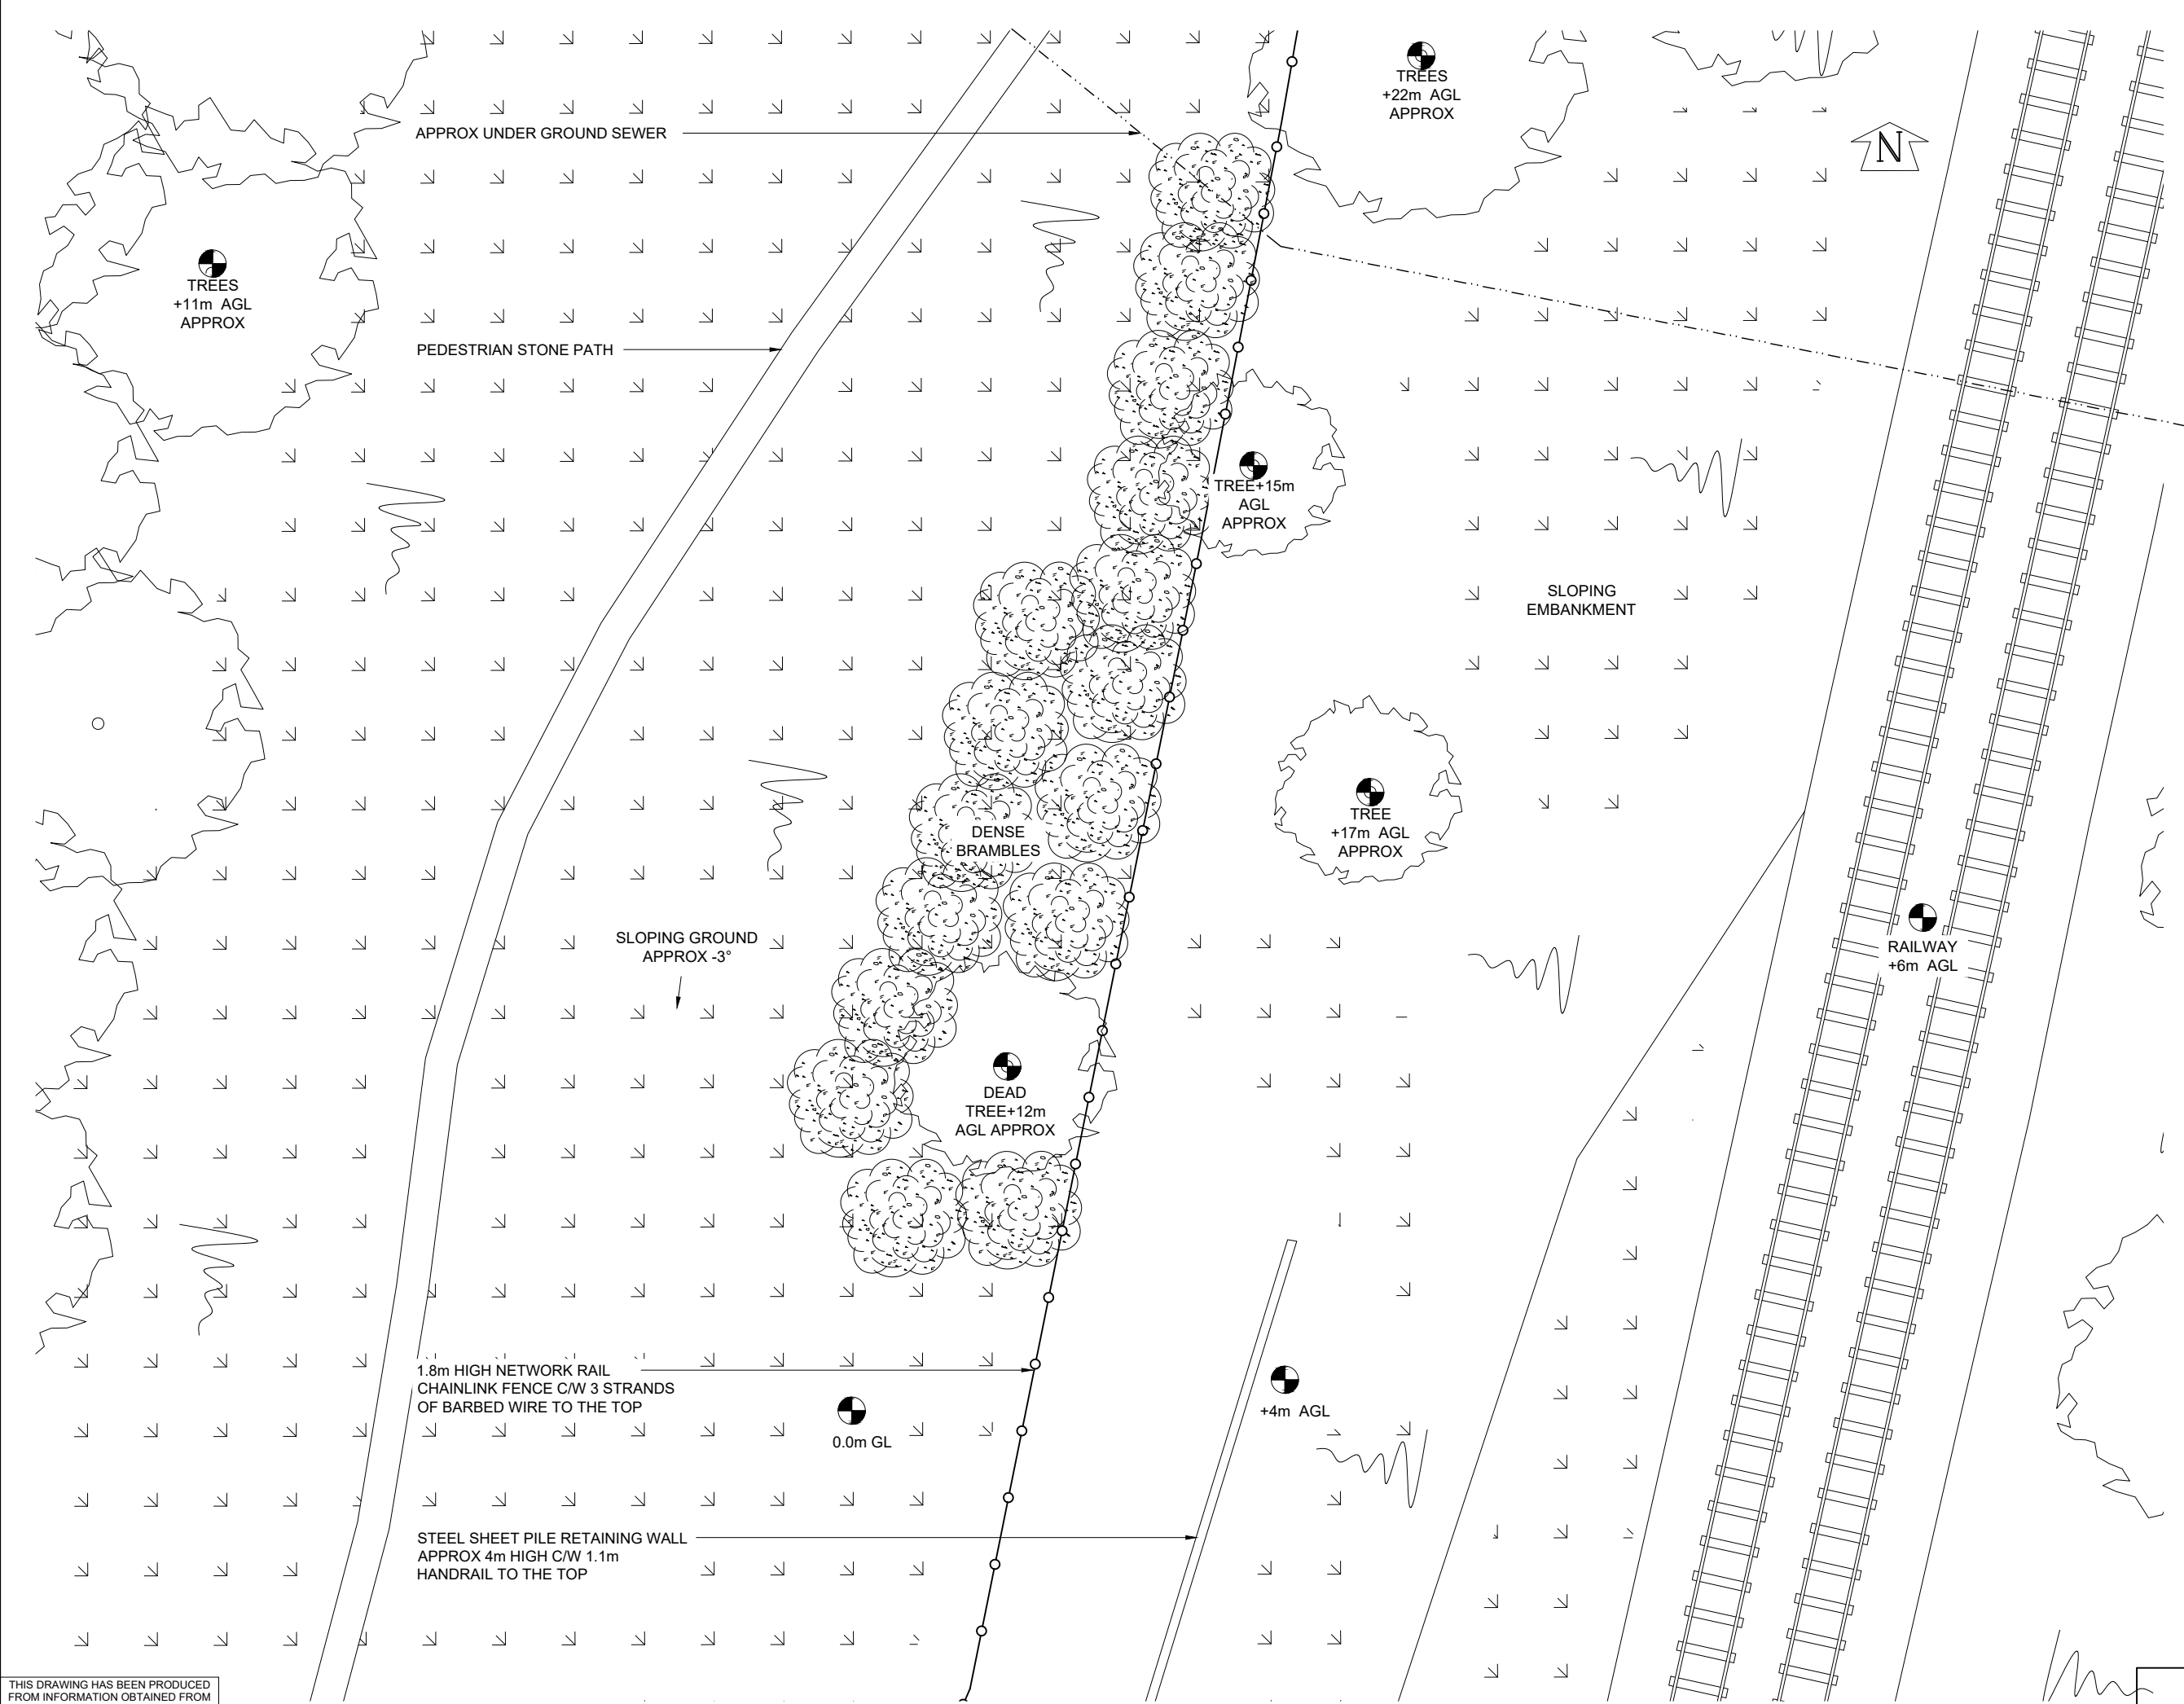

THIS DRAWING HAS BEEN PRODUCED FROM INFORMATION OBTAINED FROM SITE SURVEY ON 03/06/24. PHOTOS ARE AVAILABLE.

©2020 Cellnex
All rights reserved. No part of this publication may be reproduced, stored in a retrieval system or transmitted in any form or by any means (Electronic, Mechanical, Photocopying, Recording or otherwise), without the prior written consent of the Company.

NOTES
UNDERGROUND SERVICES
UNDERGROUND SERVICES ARE INDICATIVE ONLY. POSITIONS SHOULD BE CONFIRMED ON SITE PRIOR TO ANY DEVELOPMENT

DRAINAGE
DUCTS
FEEDERS
FENCE PLAN
GAS
LIGHTNING PROTECTION - EARTHING

POWER
SERVICES UNKNOWN
TELECOMS
WATER

ACCESS ARRANGEMENTS
KEYS:-

ARQVA GATE KEY	▲
B KEY	▲
C KEY	▲
LEGGE KEY	▲

SURVEY REQUIRED TO CONFIRM ACCESS KEYS FOR REMAINING ROOMS AND SITE ENTRANCE

3	ACCESS ROUTE CHANGE	13/12/24	ST	CIR
2	FENCE CHANGED	13/12/24	ST	CIR
1	PLANNING AMENDS	25/11/24	ST	CIR
ISS	REVISION	DATE	DRN	APP

cellnex
driving telecom connectivity

CELLNEX UK
R+, 4TH FLOOR, 2 BLAGRAVE STREET, READING, RG1 1AZ
Tel. 020 4526 8553

SITE No **S5-13A**

LAND TO THE NORTH OF LEYLAND
GRANGE CLOSE
WORLD'S END
BURGESS HILL
WEST SUSSEX
RH15 0RZ

NGR **TQ 32106 20277**

OS GRID **532106,120277**

TITLE
**SITE PLAN
EXISTING**

SCALE **1:200**

DRAWN	KG	20/06/24
APPROVED	CIR	14/01/25

DRG No.	Sheet 1 of 1	Rev
S5-13A-00-000-MD003		3