



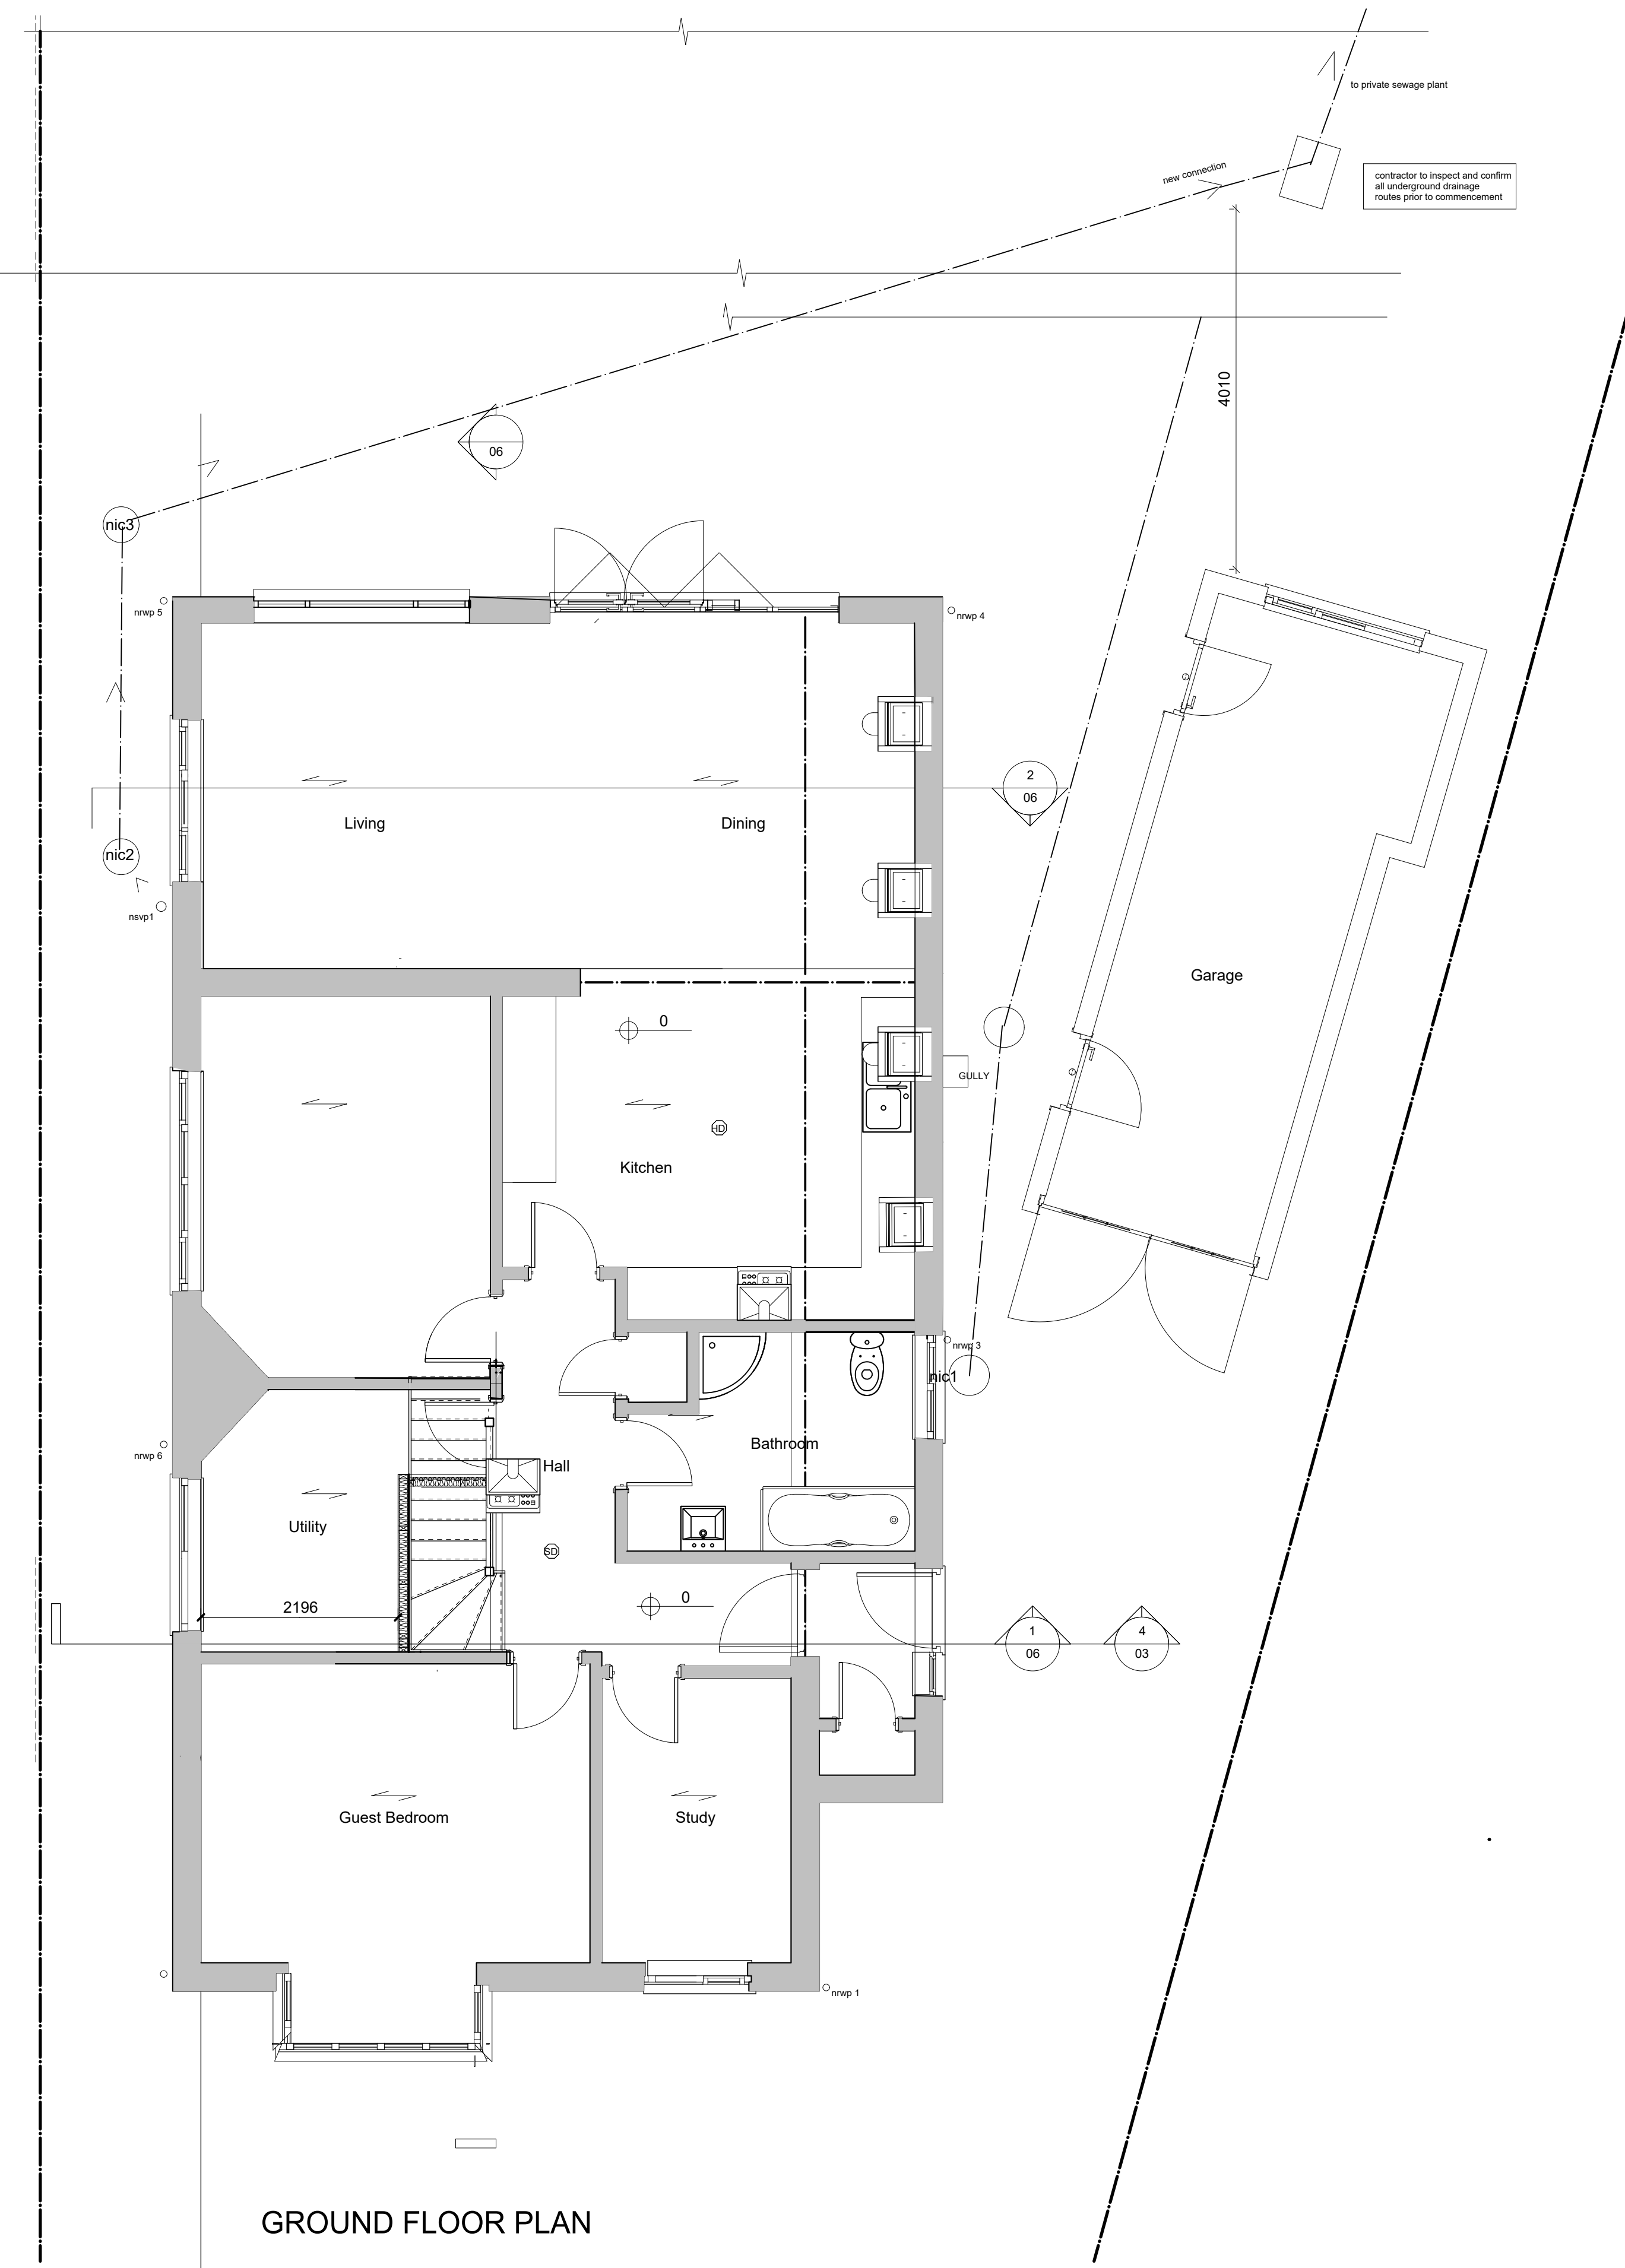

Legend			
	demolished structure over		new soil vent pipe
	100mm dia drainage		new rainwater pipe
	32/38mm dia drainage		spot level
			new window
			new inspection chamber
			joist span over
			heat detector
			smoke detector
			mechanical vent

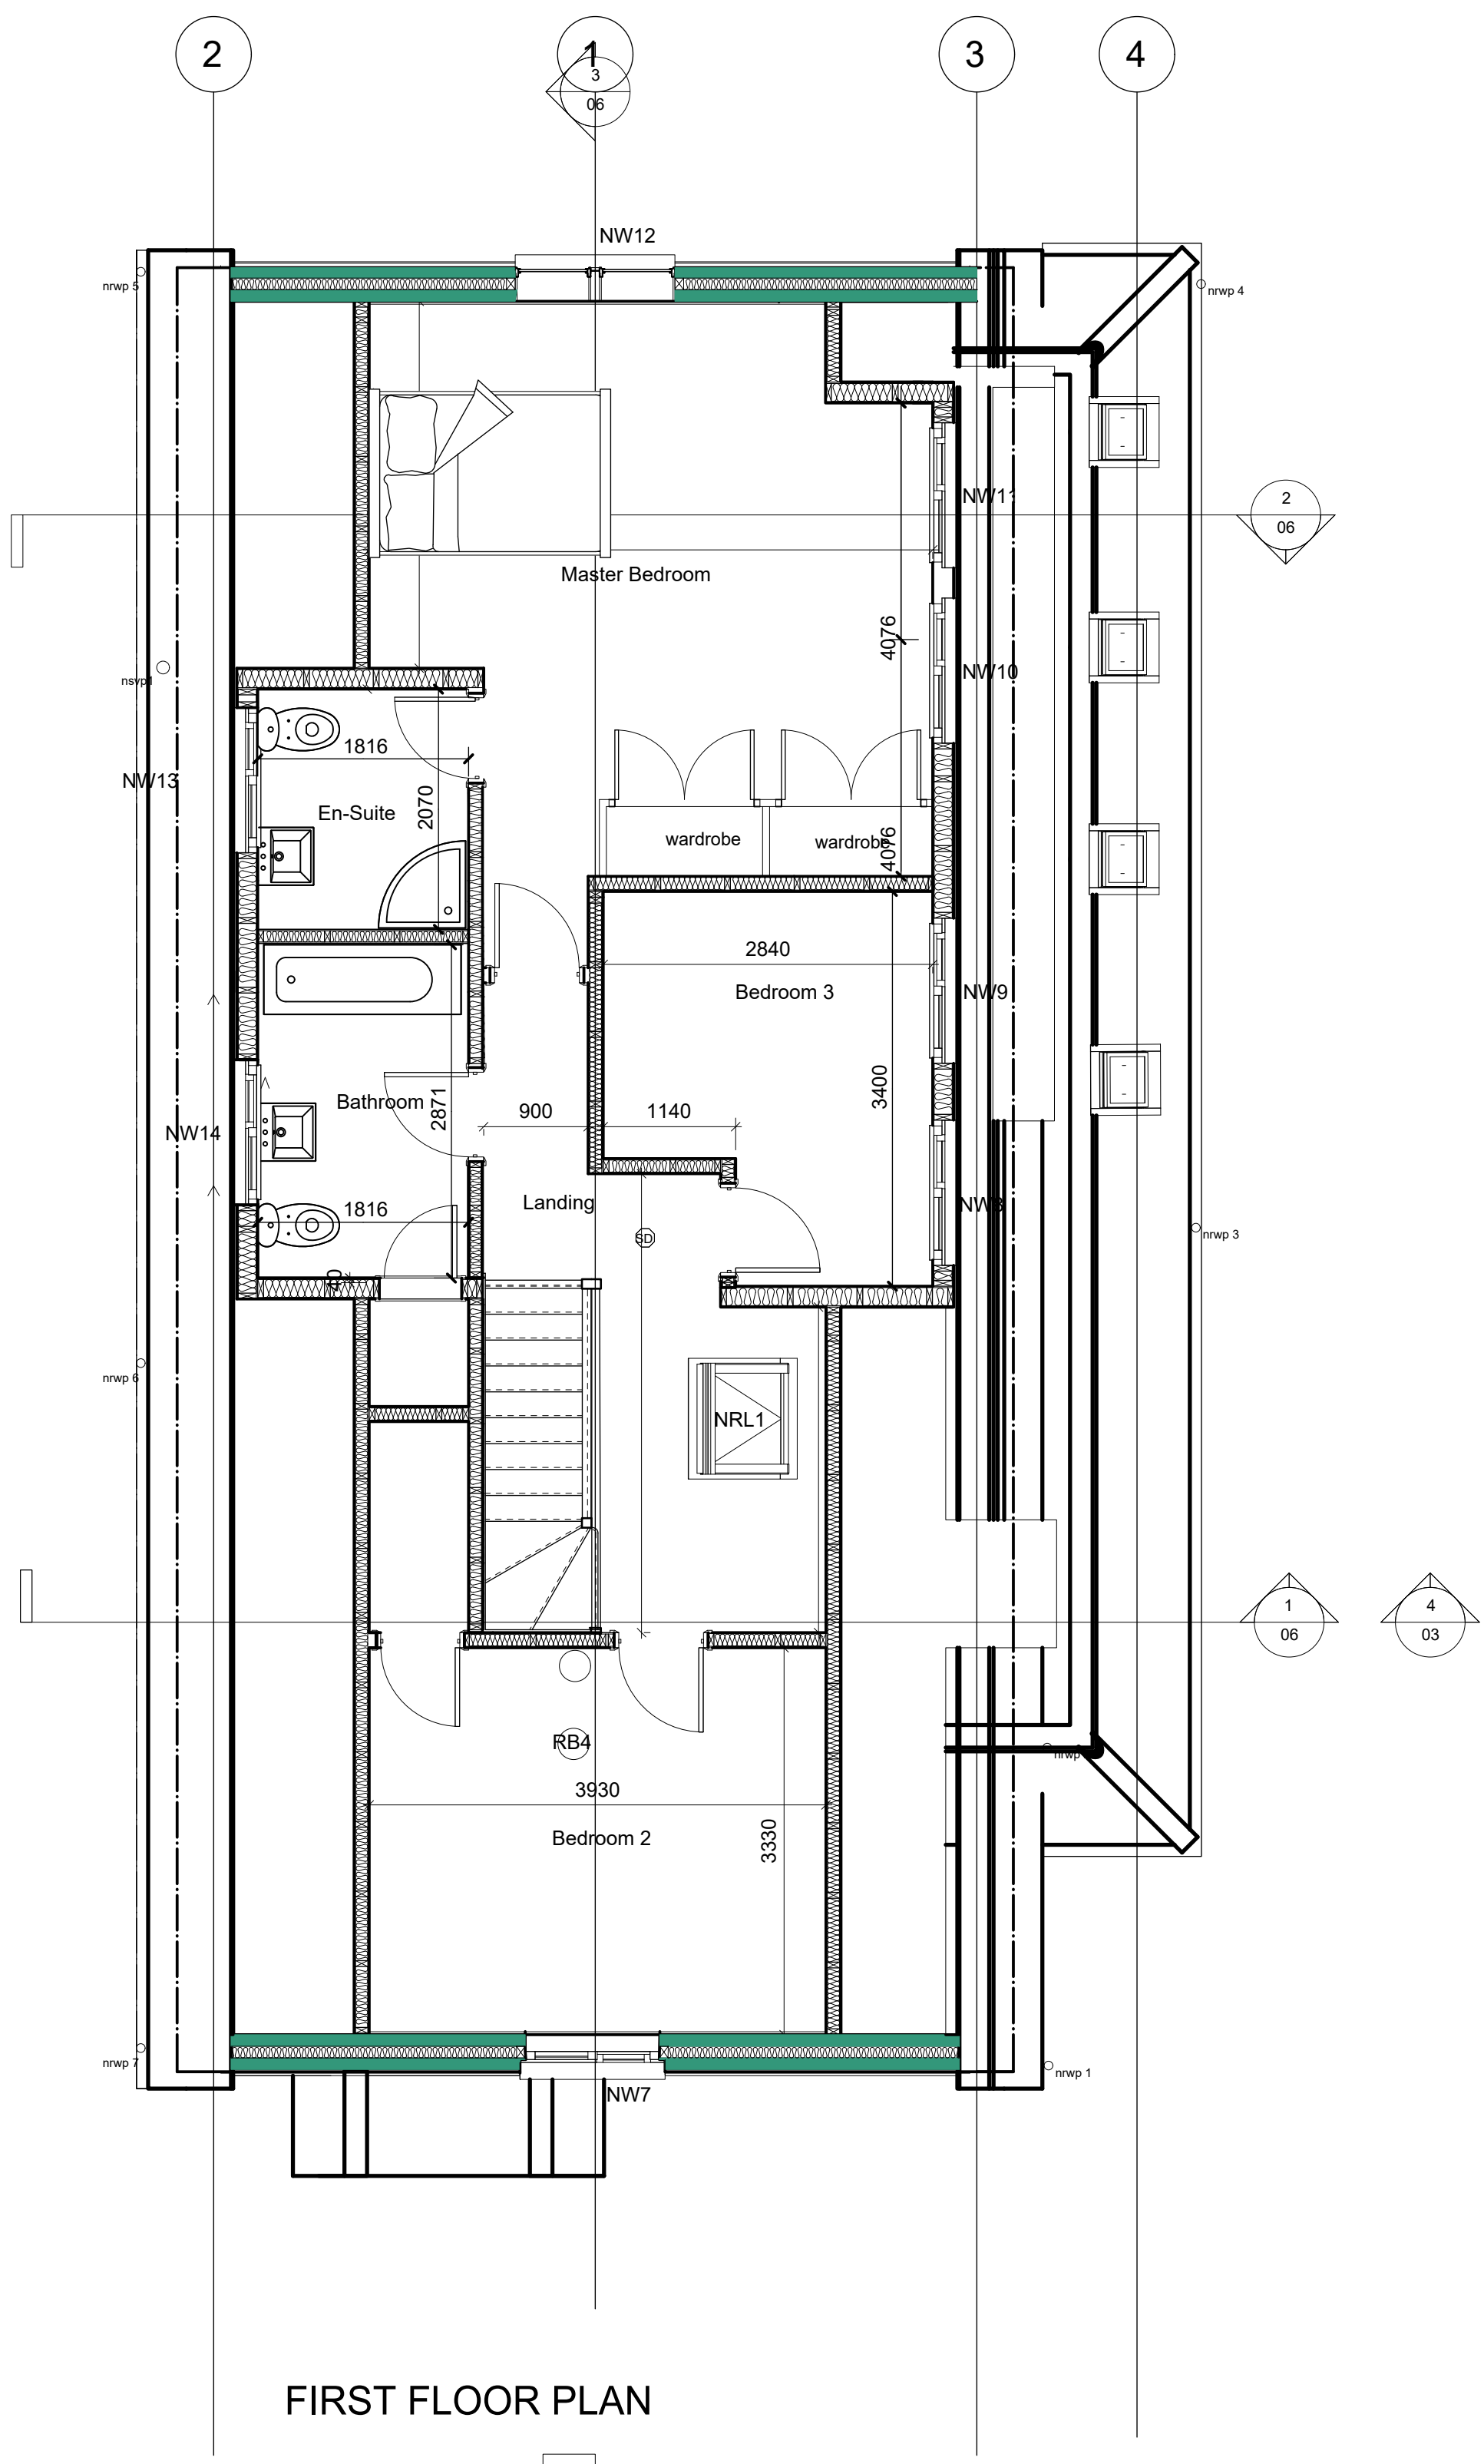

Notes:

All dimensions must be checked on site and Not scaled from this drawing.
Report any discrepancies to Surveyors before works proceed further

A		Date	Revisions
© copyright			
Les Humphrey Associates Architecture · Chartered Surveyors · Designers			
The Studio - The Rocks Ivy Dene Lane Ashurst Wood West Sussex RH19 3TN telephone: 01342 315206 fax: 01342 313984 email: les@leshumphreyassociates.co.uk			
Client			
MR & MRS WALLENDER			
Job Title			
Alterations and Extensions at: 15, Stream Park, Felbridge, West Sussex, RH19 1QN			
Drawing Title			
FLOOR PLANS AS PROPOSED			
Scale 1 : 50 when printed @ A1			
Date	20-12-2025	Drawn by	lah
Drg. No.		Rev	
191125-01			