 



Notes:
Do not scale this drawing.
All levels and dimensions are to be checked on site.
This drawing is to be read in conjunction with all relevant consultants drawings and specifications, together with safety plan requirements.
Copyright: This drawing must not be copied, amended nor reproduced without the prior written agreement.

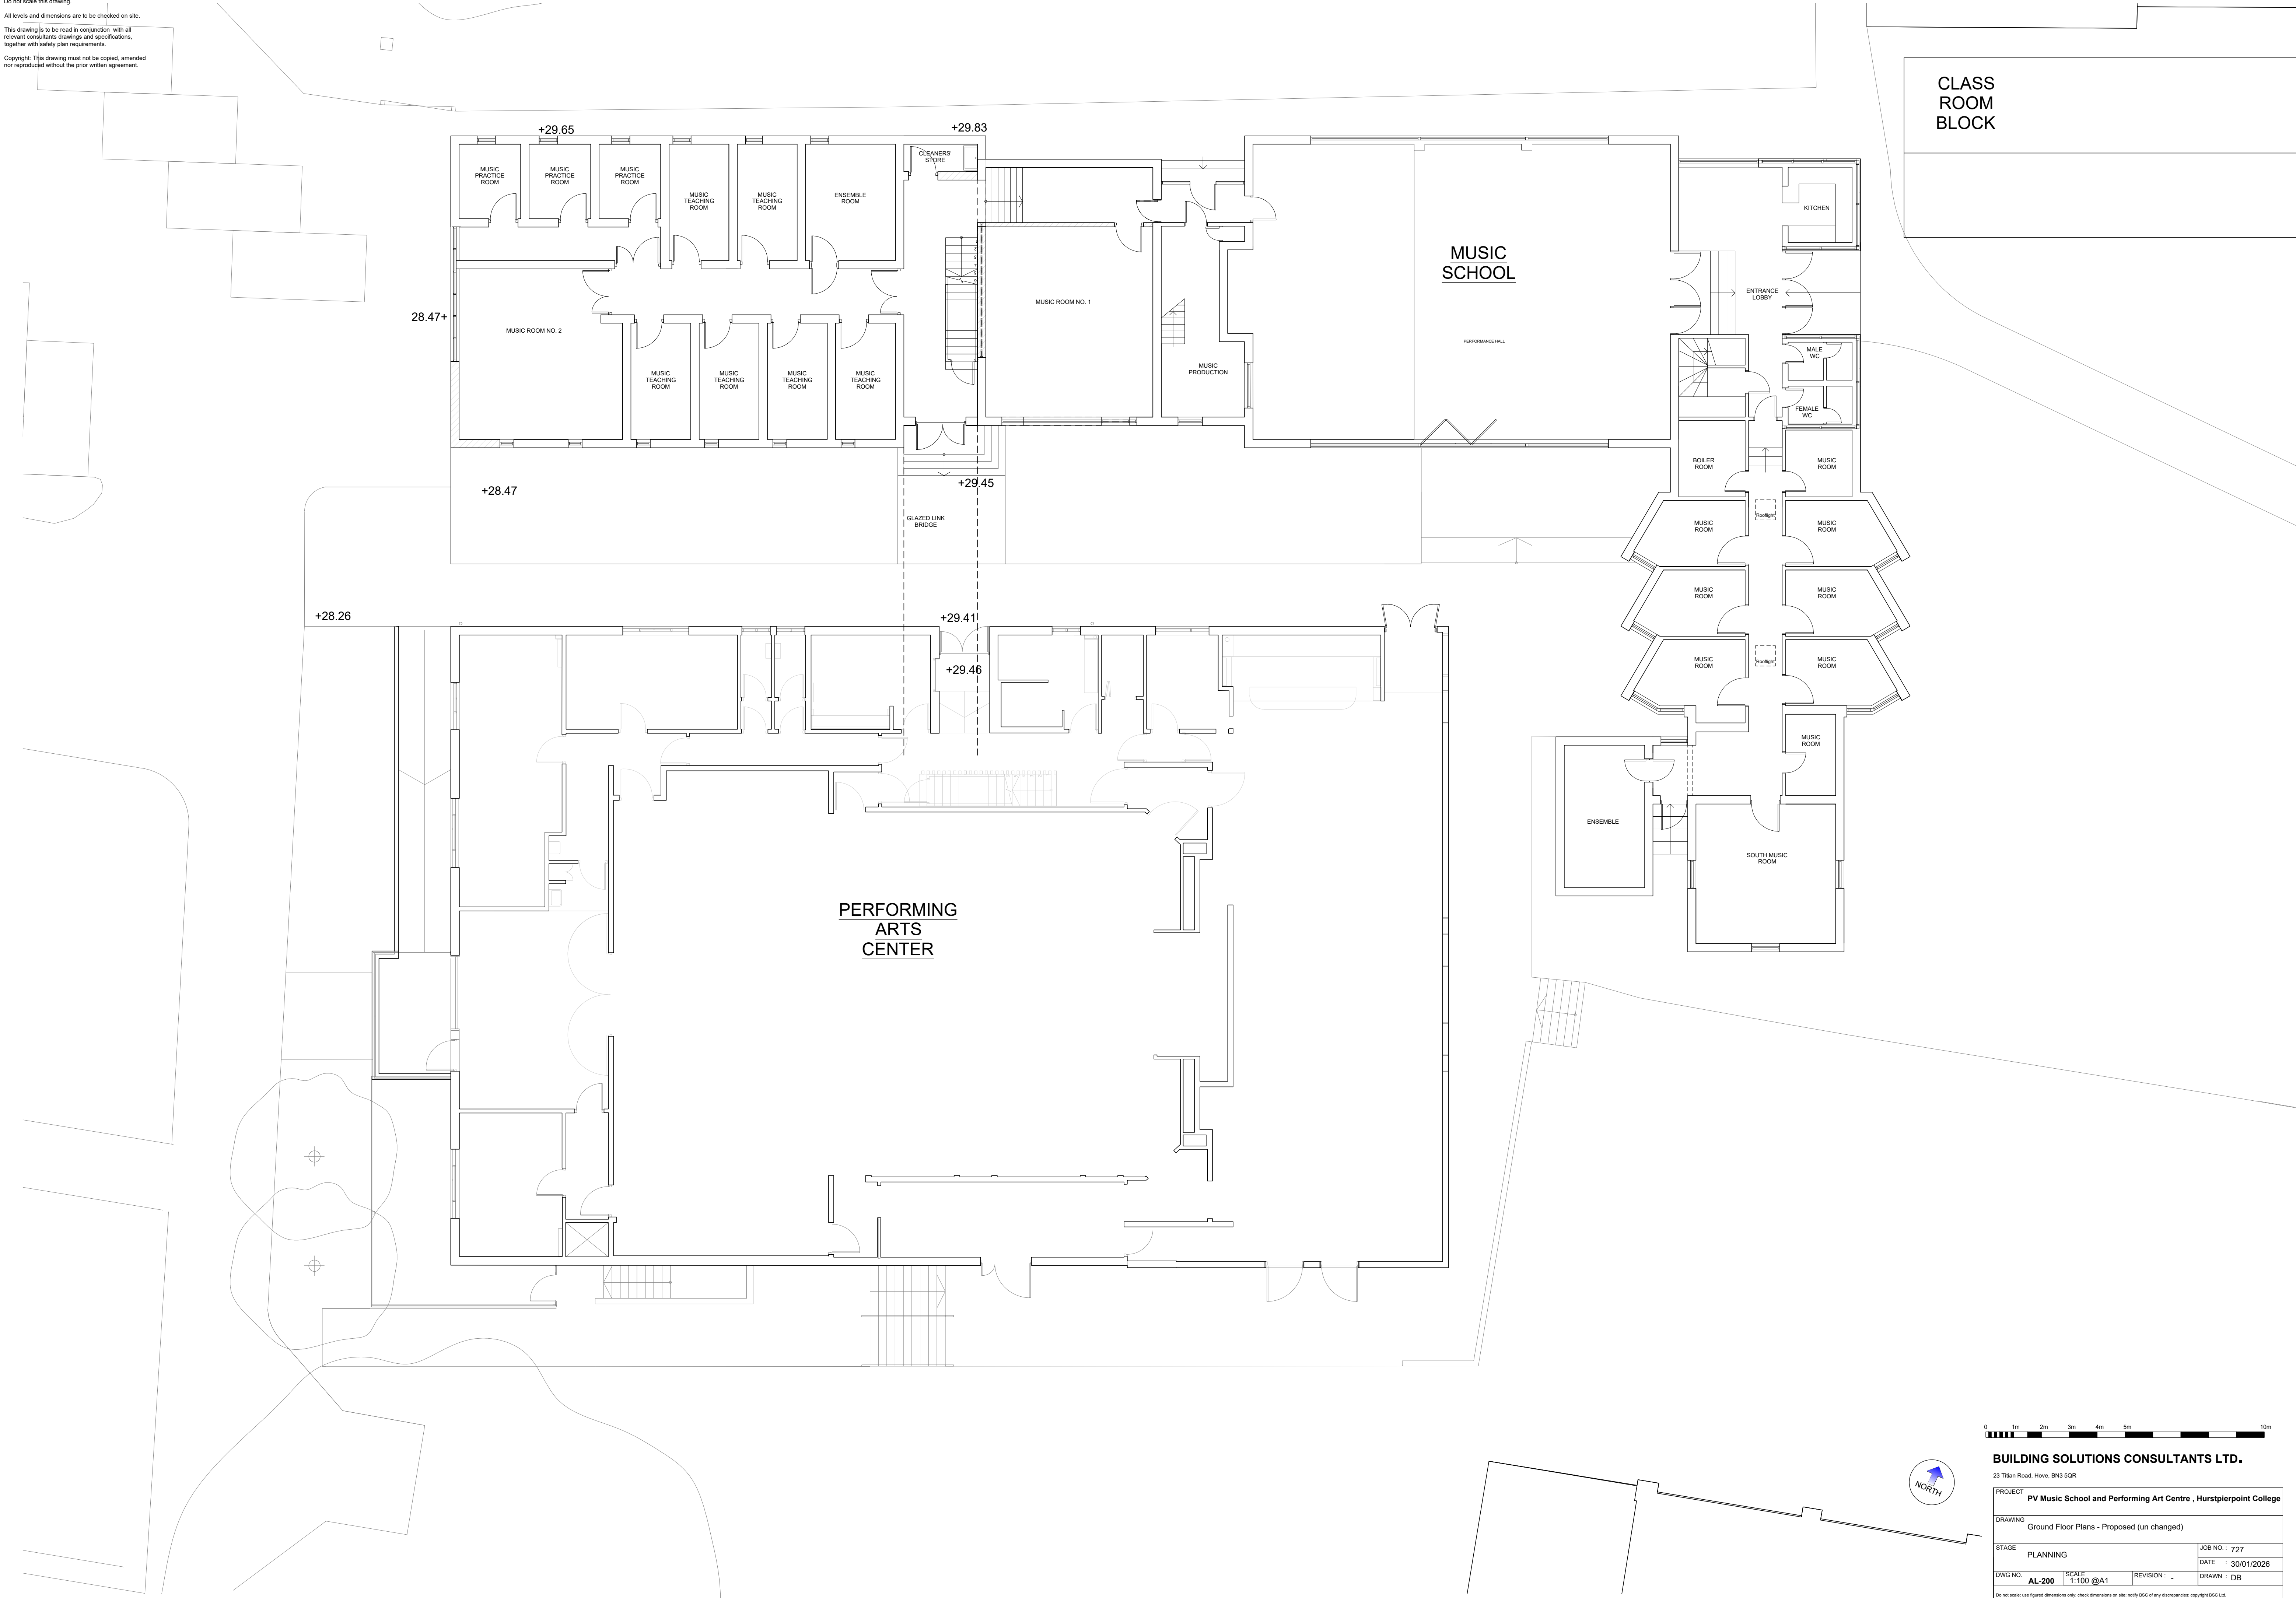

BUILDING SOLUTIONS CONSULTANTS LTD. 23 Titian Road, Hove, BN3 5QR			
PROJECT PV Music School and Performing Art Centre , Hurstpierpoint College			
DRAWING Ground Floor Plans - Proposed (un changed)			
STAGE PLANNING			JOB NO. : 727
DATE : 30/01/2026			
DWG NO. AL-200	SCALE 1:100 @A1	REVISION : -	DRAWN : DB
Do not scale. Use Spigot dimensions only. Check dimensions on site. Notify BSC if any discrepancies. copyright BSC Ltd.			