
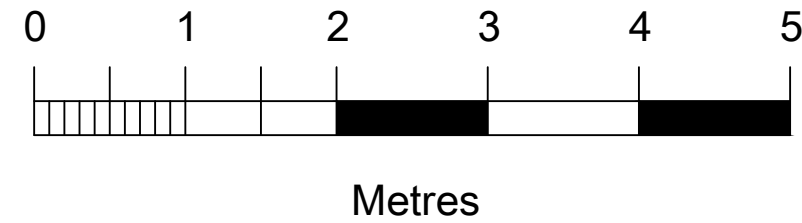


1  
534742.387 E  
125568.734 N  
45.218 L

2  
534741.916 E  
125558.526 N  
44.961 L

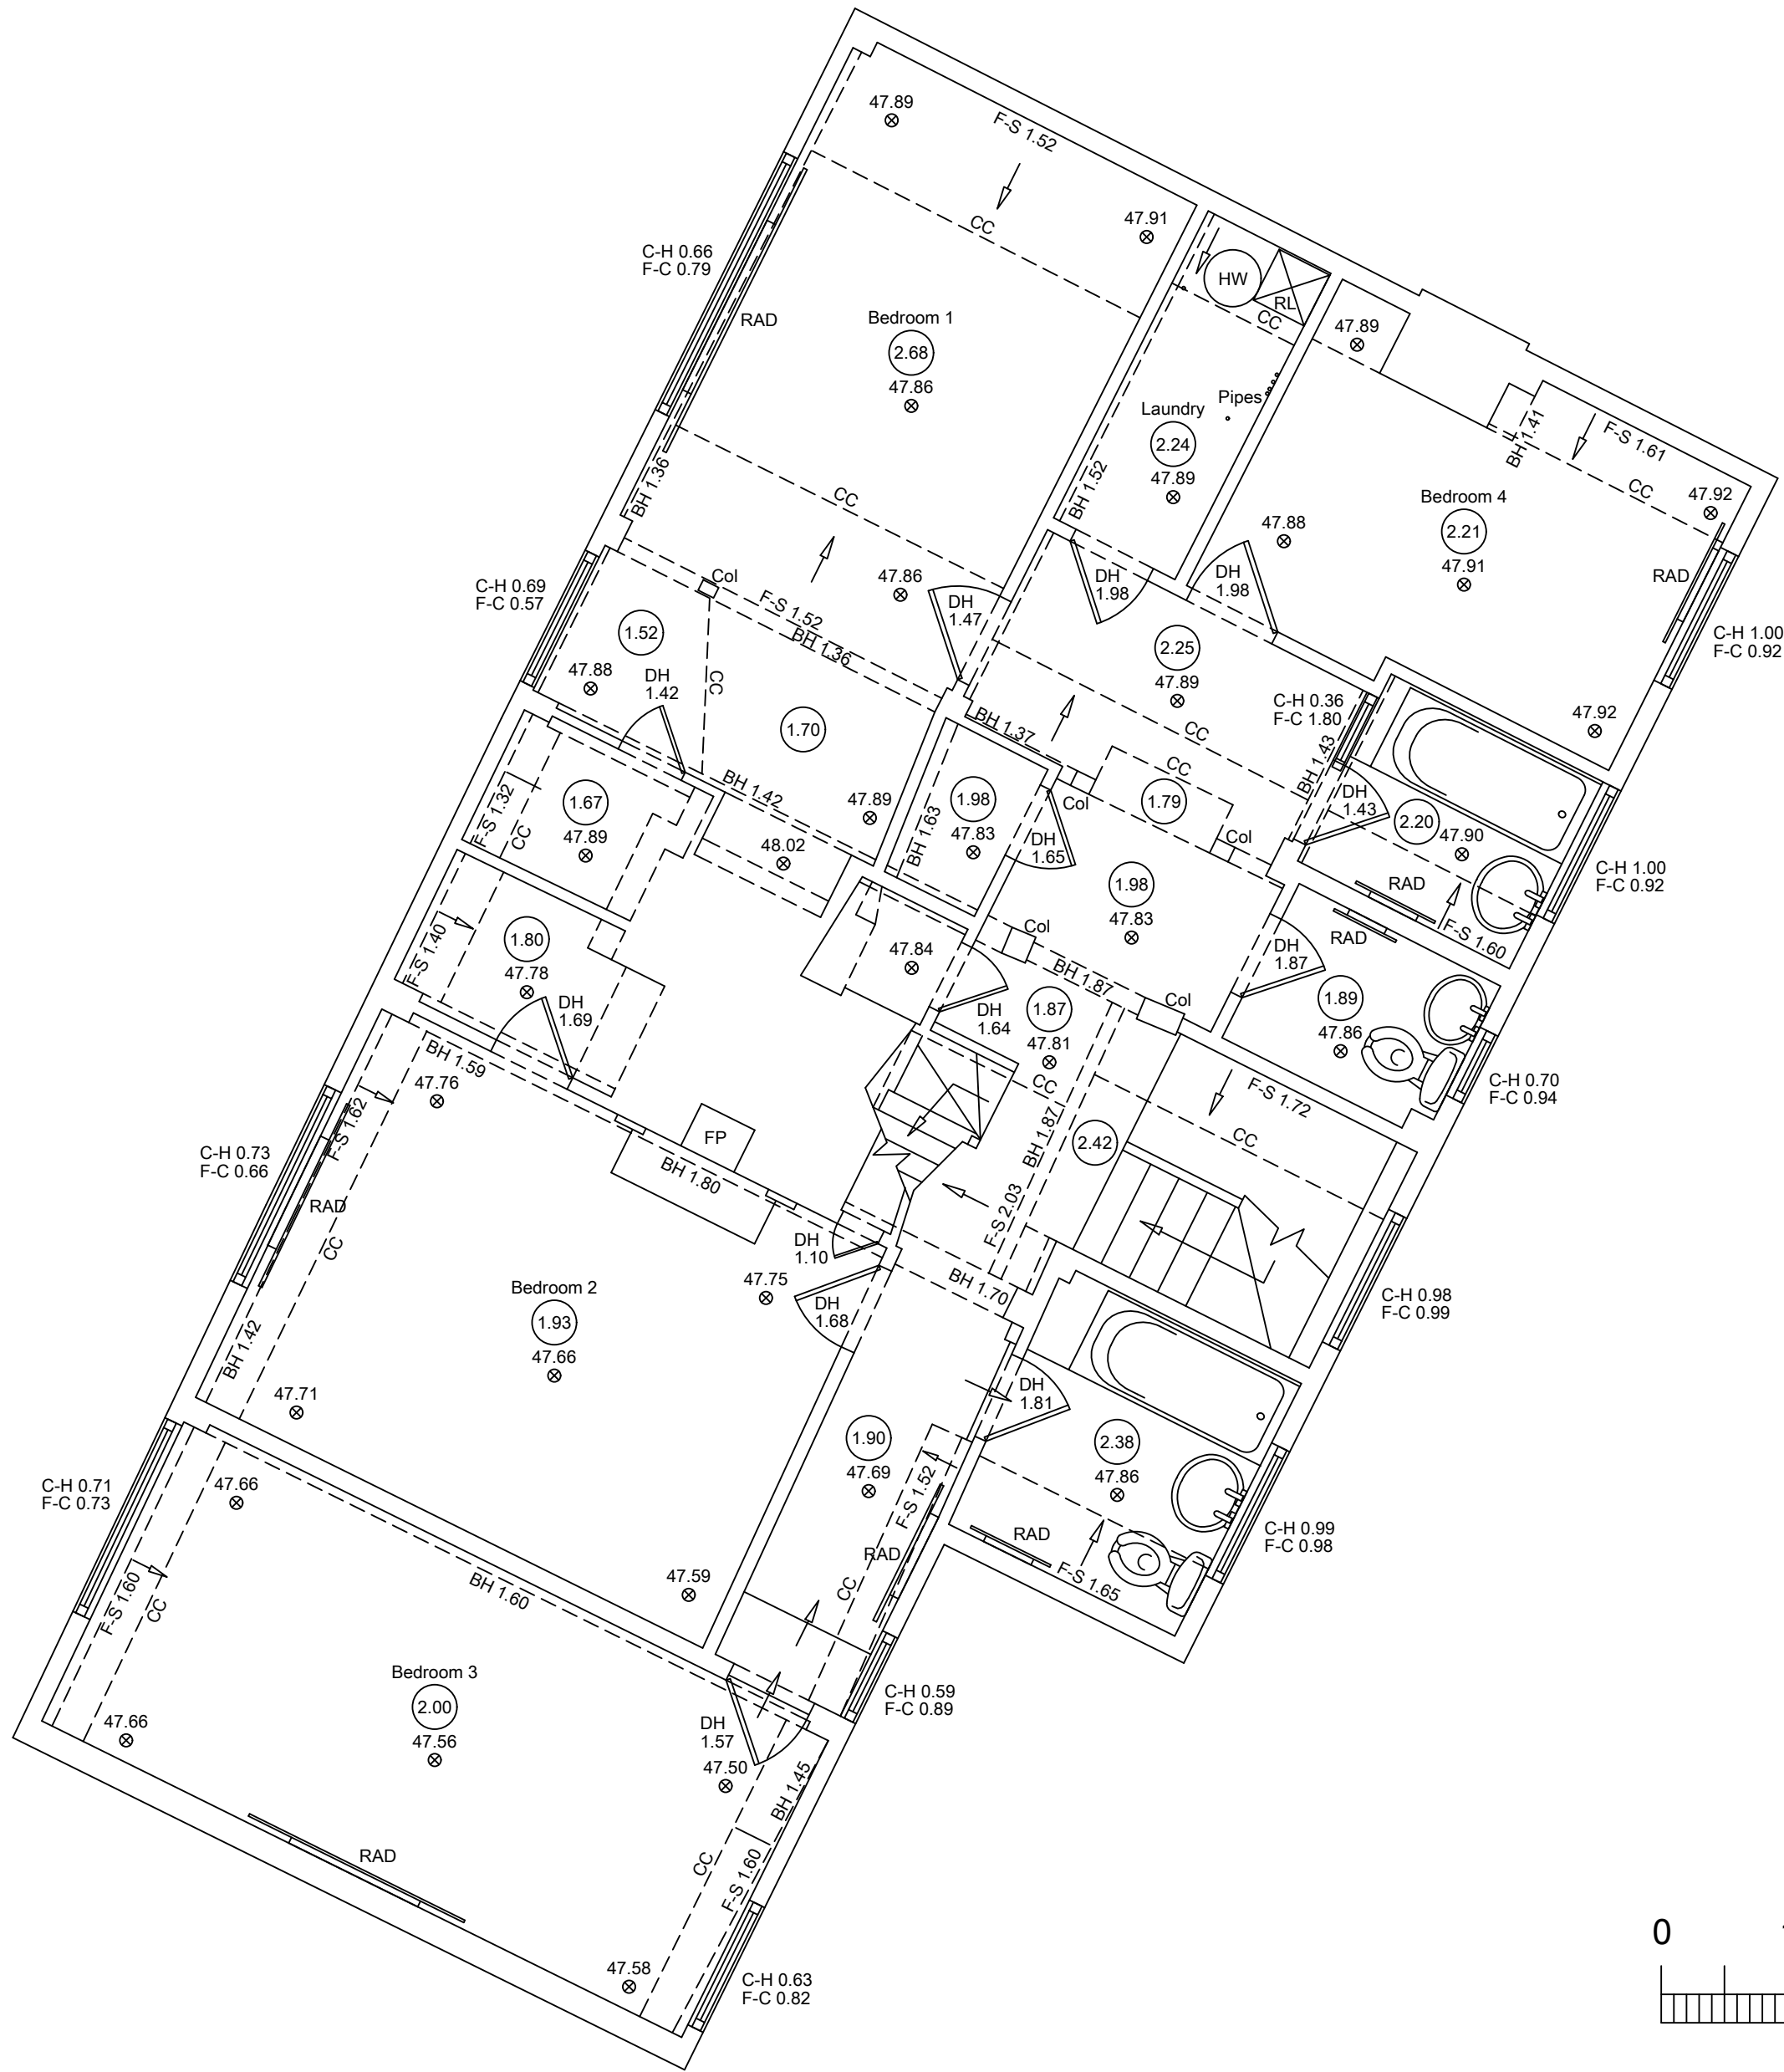

copyright

Copyright of this drawing is retained by City Geomatics Ltd. Any discrepancies between this drawing and any other information should be reported to City Geomatics Ltd.

Drawing Naming Convention:

Job No/Dwg type/Location/Ref

Dwg Type: B = Building, S = Section, E = Elevation, T = Topographical

Location: B = Basement, C = Ceiling Plan, E = External, F = Front, S = Side, R = Rear, GA = General Layout, M = Mezzanine, AA = Section A-A

Ref: Ref to individual dwg I.D. (e.g. Revision)

Standard Abbreviations (where applicable):

| Building Survey           | Land Survey          |
|---------------------------|----------------------|
| AB AIR BRICK              | B BOLLARD            |
| ACU AIR CONDITIONING UNIT | BB BELISHA BEACON    |
| AH ACCESS HATCH           | BT B.T. COVER        |
| AP ACCESS PANEL           | CAM CAMERA           |
| AV AIR VALVE              | CATV CABLE TV COVER  |
| BH BEAM HT                | CL COVER LEVEL       |
| BR BOILER                 | ELEC ELECTRIC COVER  |
| BSL BEAM SOFFIT LEVEL     | EP ELECTRIC POLE     |
| CB CURB/ROAD              | ER EARTH ROD         |
| CC CEILING CHANGE         | FP FLAG POLE         |
| CH CLEAR INTERNAL HT      | FW FOUL WATER        |
| C-A CILL TO APEX HT       | GU GULLY             |
| C-H CILL TO HEAD HT       | GV GAS VALVE         |
| C-S CILL TO SPRING HT     | FH FIRE HYDRANT      |
| DB DOOR BASE HT           | IC INSPECTION COVER  |
| DH DOOR HEAD HT           | IL INVERT LEVEL      |
| DR DRAIN                  | LP LAMP POST         |
| EXP EXTRACTOR FAN         | MH MANHOLE           |
| FA FIRE ALARM             | OHT OVERHEAD TELECOM |
| F-A FLOOR TO APEX HT      | P POST               |
| F-C FLOOR TO CILL HT      | PM PARKING METER     |
| F-H FLOOR TO HEAD HT      | PI PIPE              |
| F-S FLOOR TO SPRING HT    | RD RODDING EYE       |
| GEA GROSS EXTERNAL AREA   | RS ROAD SIGN         |
| GIA GROSS INTERNAL AREA   | RTW RETAINING WALL   |
| GU GULLY                  | RWP RAIN WATER PIPE  |
| HT HEATER                 | SA SITE AREA         |
| HW HOT WATER TANK         | SI SICK              |
| NIA NET INTERNAL AREA     | SL SOFFIT LEVEL      |
| NTS NOT TO SCALE          | SV STOP VALVE        |
| RAD RADIATOR              | SVP SOIL VENT PIPE   |
| RE RECESS HEAD HEIGHT     | SW STORM WATER       |
| RFV RAISED FLOOR VOID     | TCF TOP OF FENCE     |
| RL ROOF LIGHT             | TOW TOP OF WALL      |
| RSH ROLLER SHUTTER        | TP TELEGRAPH POLE    |
| RWP RAIN WATER PIPE       | UTL UNABLE TO LIFT   |
| SVP SOIL VENT PIPE        | VP VENT PIPE         |
| V VENT                    | WM WATER METER       |
| WA WARDROBE               | WT WATER TAP         |

Symbols (where applicable):

Direction of sloping ceiling

PLUG SOCKET 2-NO. OF SOCKETS

LIGHT SWITCH 1-NO. OF SWITCHES

FLOOR TO STRUCTURAL CEILING HT

FLOOR TO SUSPENDED CEILING HT

FLOOR LEVEL RELATIVE TO DATUM

Notes:

The Survey has been computed on the OS grid.

All Levels are in metres and relate to OS datum.

All direction arrows indicate UP unless otherwise stated.

Drainage pipe sizes (where shown) have been gauged from the surface (for safety reasons) and should be regarded as approximate only.

Visible features in the vicinity of any boundaries, as shown on this survey, may not represent the extent of legally conveyed ownership.

Whilst every effort has been made to determine wall materials, no guarantee is given. Materials should be regarded as assumed unless verified by a qualified third party.

Tree spread and height are approximate. Species should be regarded as assumed unless verified by a qualified third party.

Sheet Layout:

| Rev | Date | By | Description |
|-----|------|----|-------------|
|     |      |    |             |
|     |      |    |             |
CITY GEOMATICS

Land & Measured Building Surveyors

Horsham, West Sussex RH12 3QJ  
t. 01403 268469  
www.citygeomatics.co.uk  
enquiries@citygeomatics.co.uk

Client: Gould Baxter

Project: Crosskeys High Street Lindfield

Drawing Title: Existing First Floor Plan

| Date:    | Scale: | Surveyor: | Drawn: | Checked: |
|----------|--------|-----------|--------|----------|
| Sep - 24 | 1:50   | RD        | BP     | CGL      |

| Job No: | Drawing No:   | Sheet No: | Rev: |
|---------|---------------|-----------|------|
| 24/186  | 24186 - B - 1 | 1 of 1    | -    |

SHEET SIZE A2