



NOTES  
Do not scale from this drawing.  
Any discrepancies should be reported immediately.  
This drawing is copyright. It must not be reproduced or disclosed to third parties without our prior permission.  
This drawing is to be read in conjunction with all relevant consultants, specialist manufacturers drawings and specifications.  
Any surveyed information incorporated within this drawing cannot be guaranteed as accurate unless confirmed by fixed dimension.  
All dimensions are in millimetres unless noted otherwise.

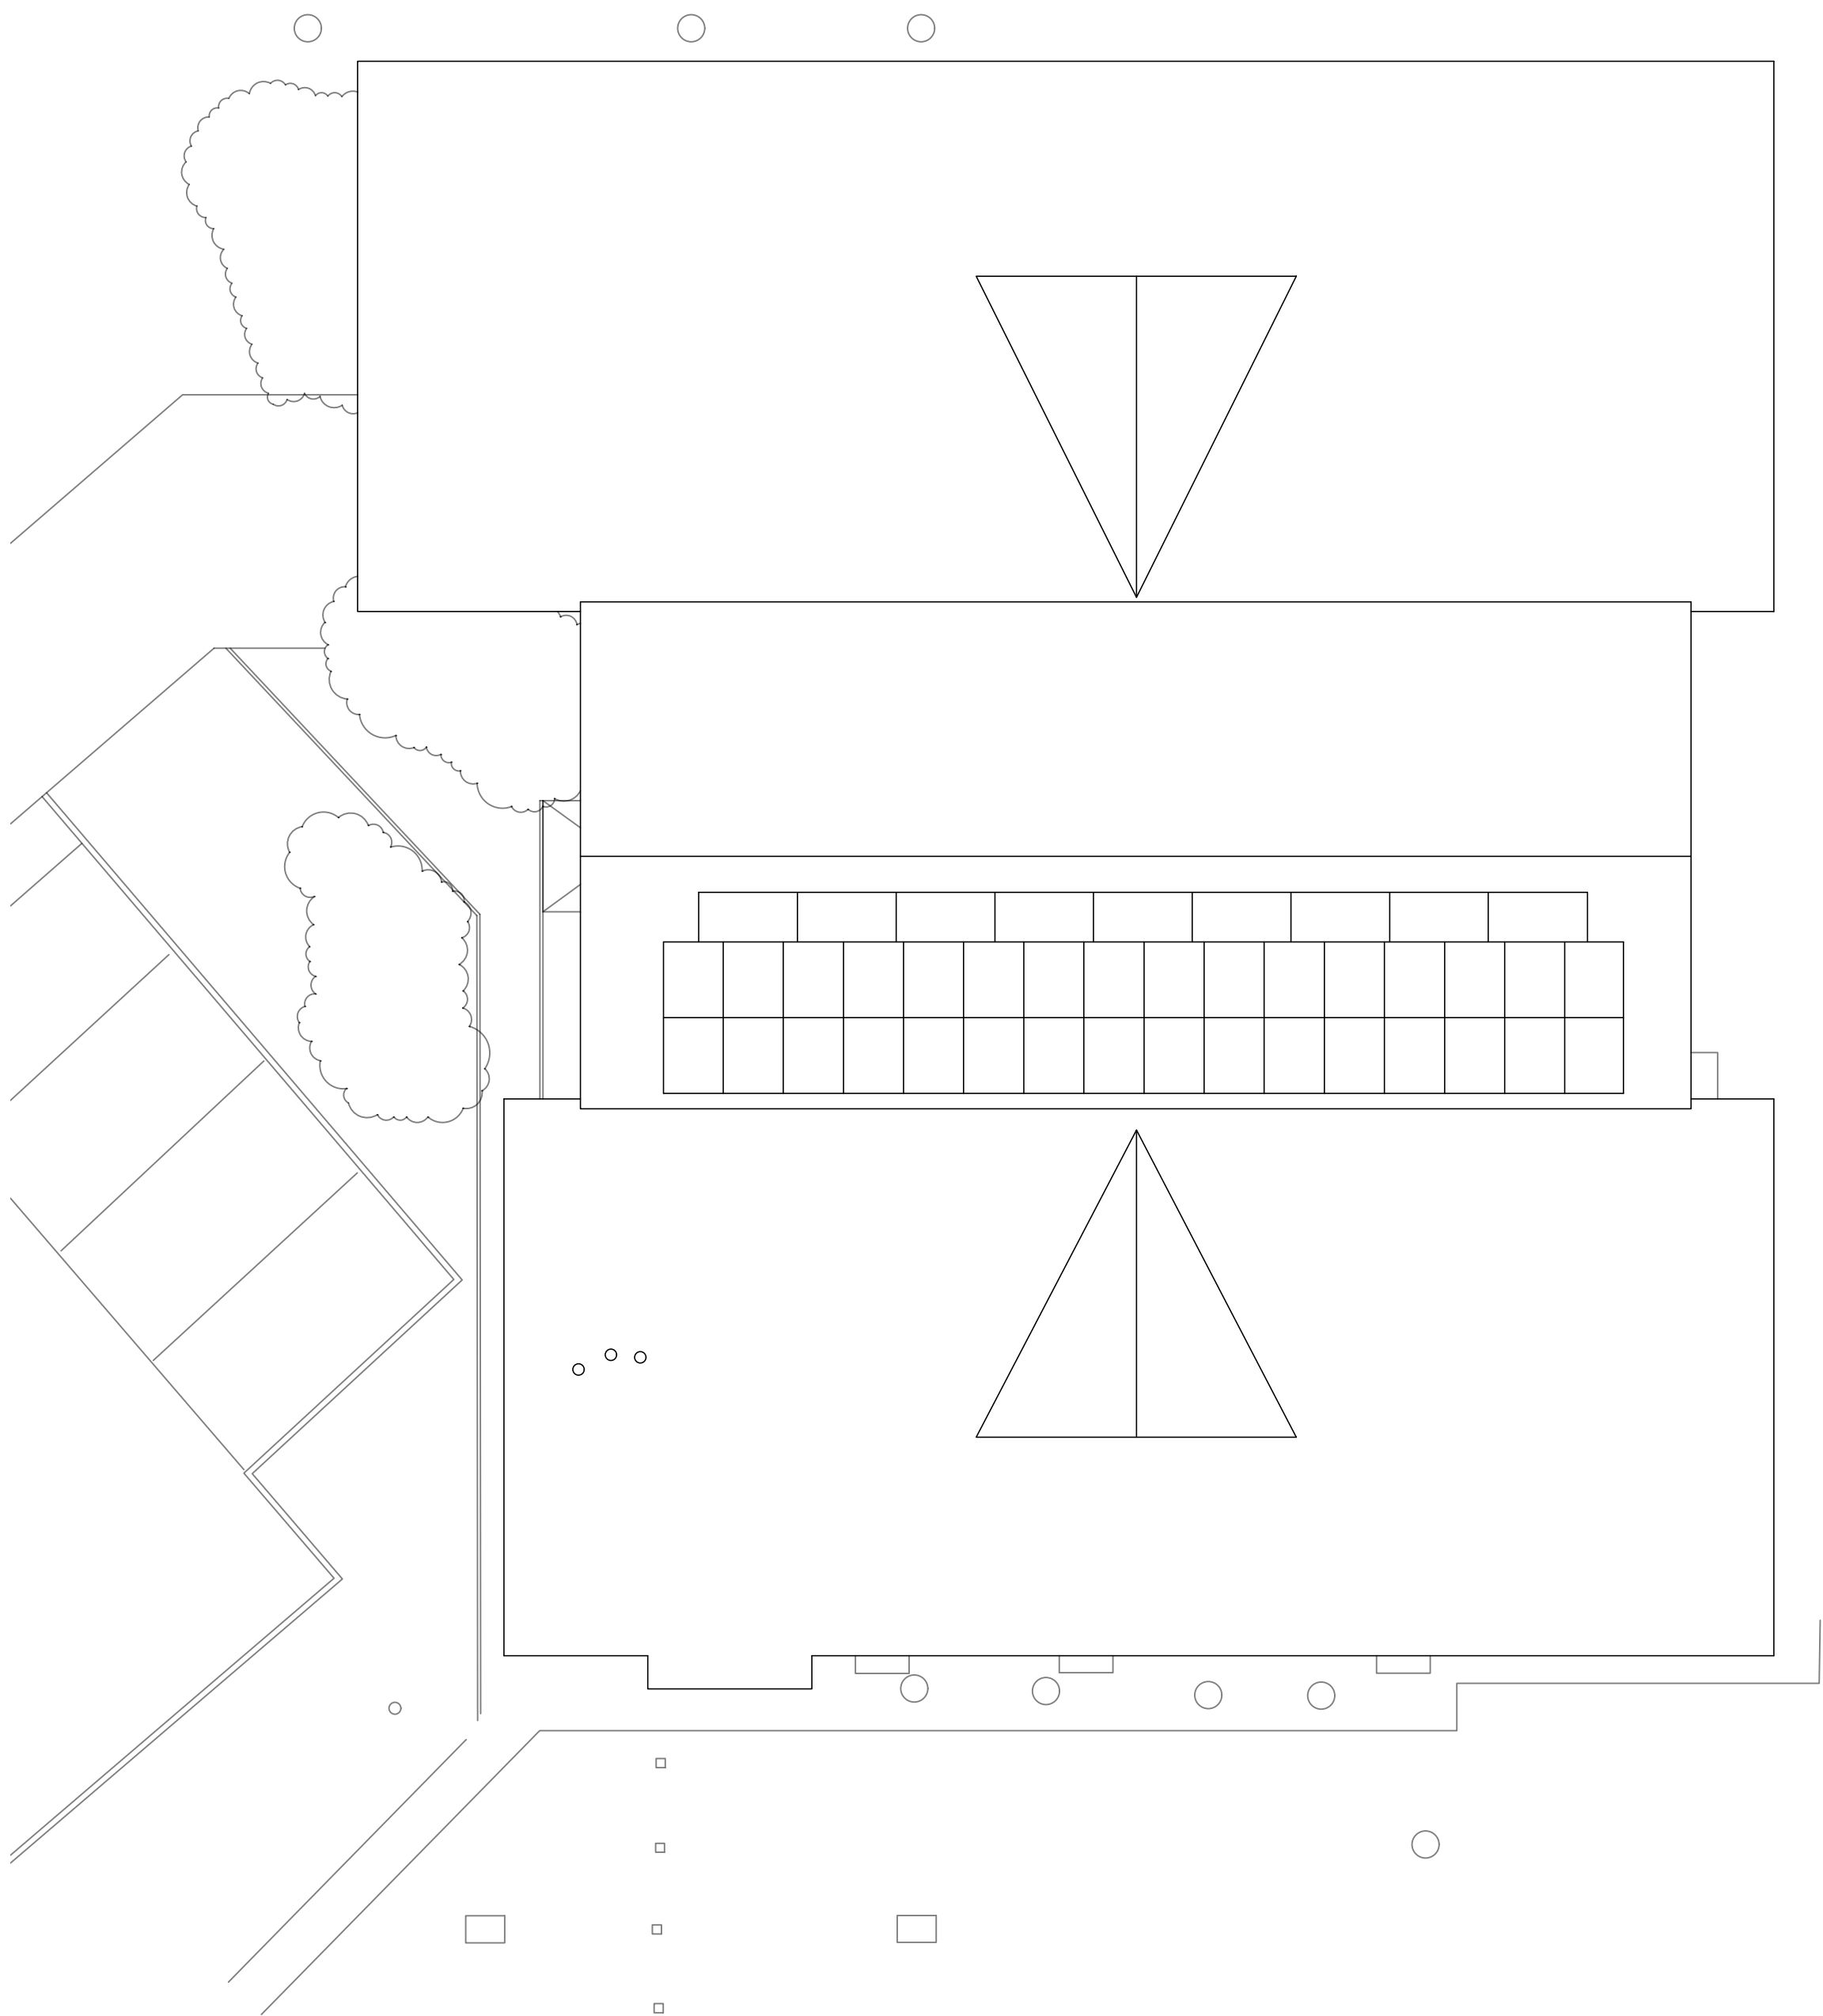

Roof Plan & Site Context Plan



1:100  
0 1m 2m 3m 4m 5m 10m
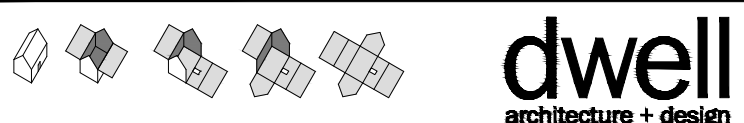
|                                                                                                          |                 |                  |           |         |
|----------------------------------------------------------------------------------------------------------|-----------------|------------------|-----------|---------|
|                     |                 |                  |           |         |
| studio@dwellarchitecture.com Tel: 01444 831 800<br>www.dwellarchitecture.com Fax: 01444 220 499          |                 |                  |           |         |
| Drawing Status                                                                                           |                 |                  |           |         |
| SURVEY                                                                                                   |                 |                  |           |         |
| Client Trustees of Scaynes Hill Millennium Village Centre                                                |                 |                  |           |         |
| Project Proposed Air Source Heat Pump Installation<br>Scaynes Hill Millennium Village Centre, Lewes Road |                 |                  |           |         |
| Title Roof Plan<br>as Existing                                                                           |                 |                  |           |         |
| Dwg. 1409 GA 03 - Rev.                                                                                   |                 |                  |           |         |
| Job No. 1409                                                                                             | Date 13/06/2025 | Scale 1:100 @ A1 | Drawn JSR | Checked |