


A

285x285x90 DEEP LED LIGHT,
BLACK BODY, 1200 LUMEN OUTPUT

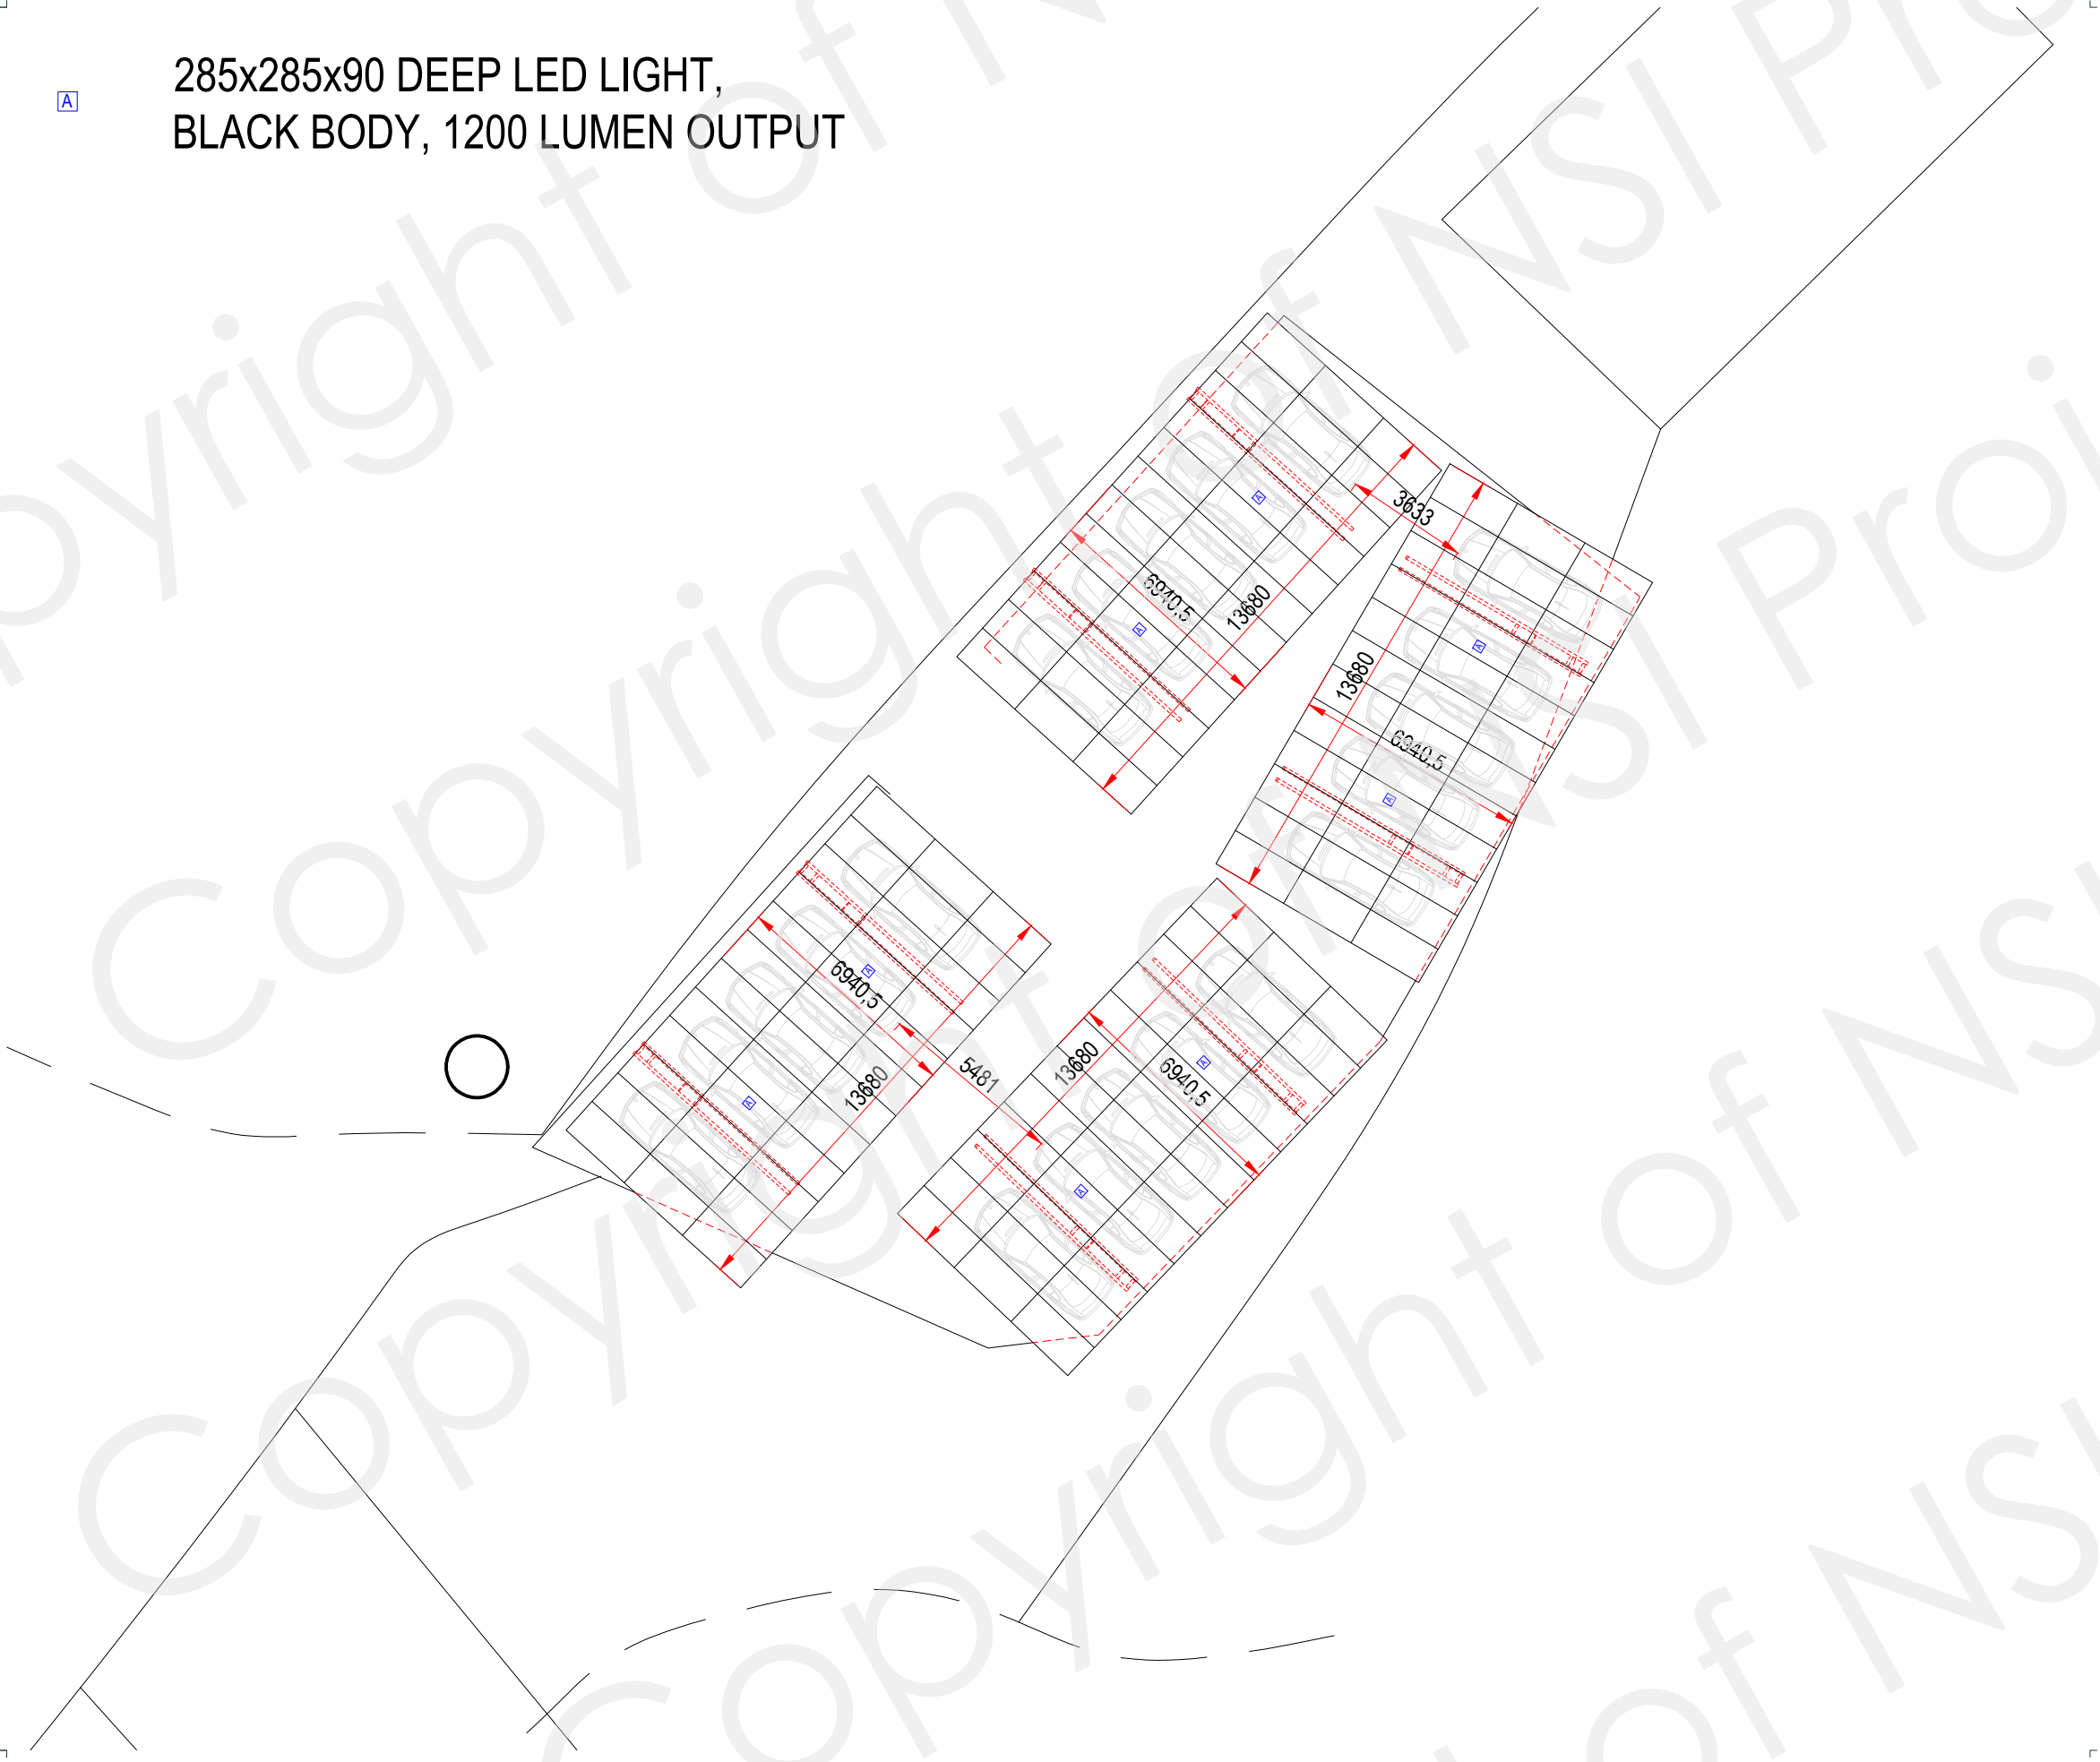

© Copyright Reserved. This drawing remains the property of Northern Storage & Interiors. It should not be copied without written consent and must be returned on request. The information is confidential and it is supplied on the condition that it will not be disclosed to a third party.

CLIENT APPROVAL

Please sign in the below box to confirm acceptance of the drawing:

Signature:		Job Role:	
Name:		Date:	

1	25/06	DH	RR	FIRST ISSUE
REV	DATE	DRN	CHK	DESCRIPTION

STATUS:

Proposal



NSI House, Station Brow, Leyland, Preston,
Lancashire, PR25 3NZ
Tel: 01772 623303
Email: sales@nsiprojects.co.uk

PROJECT:

Freshfield Lane Bricks

TITLE:

Canteen Carpark Lighting Layout

	NSI001973
DRAWING NO:	DN0081-008
DWG REVISION:	1
SCALE:	1:200 @ A3
DATE:	25/06/2025
DRAWN BY:	D HOYLE
CHECKED BY:	R RICHARDSON