


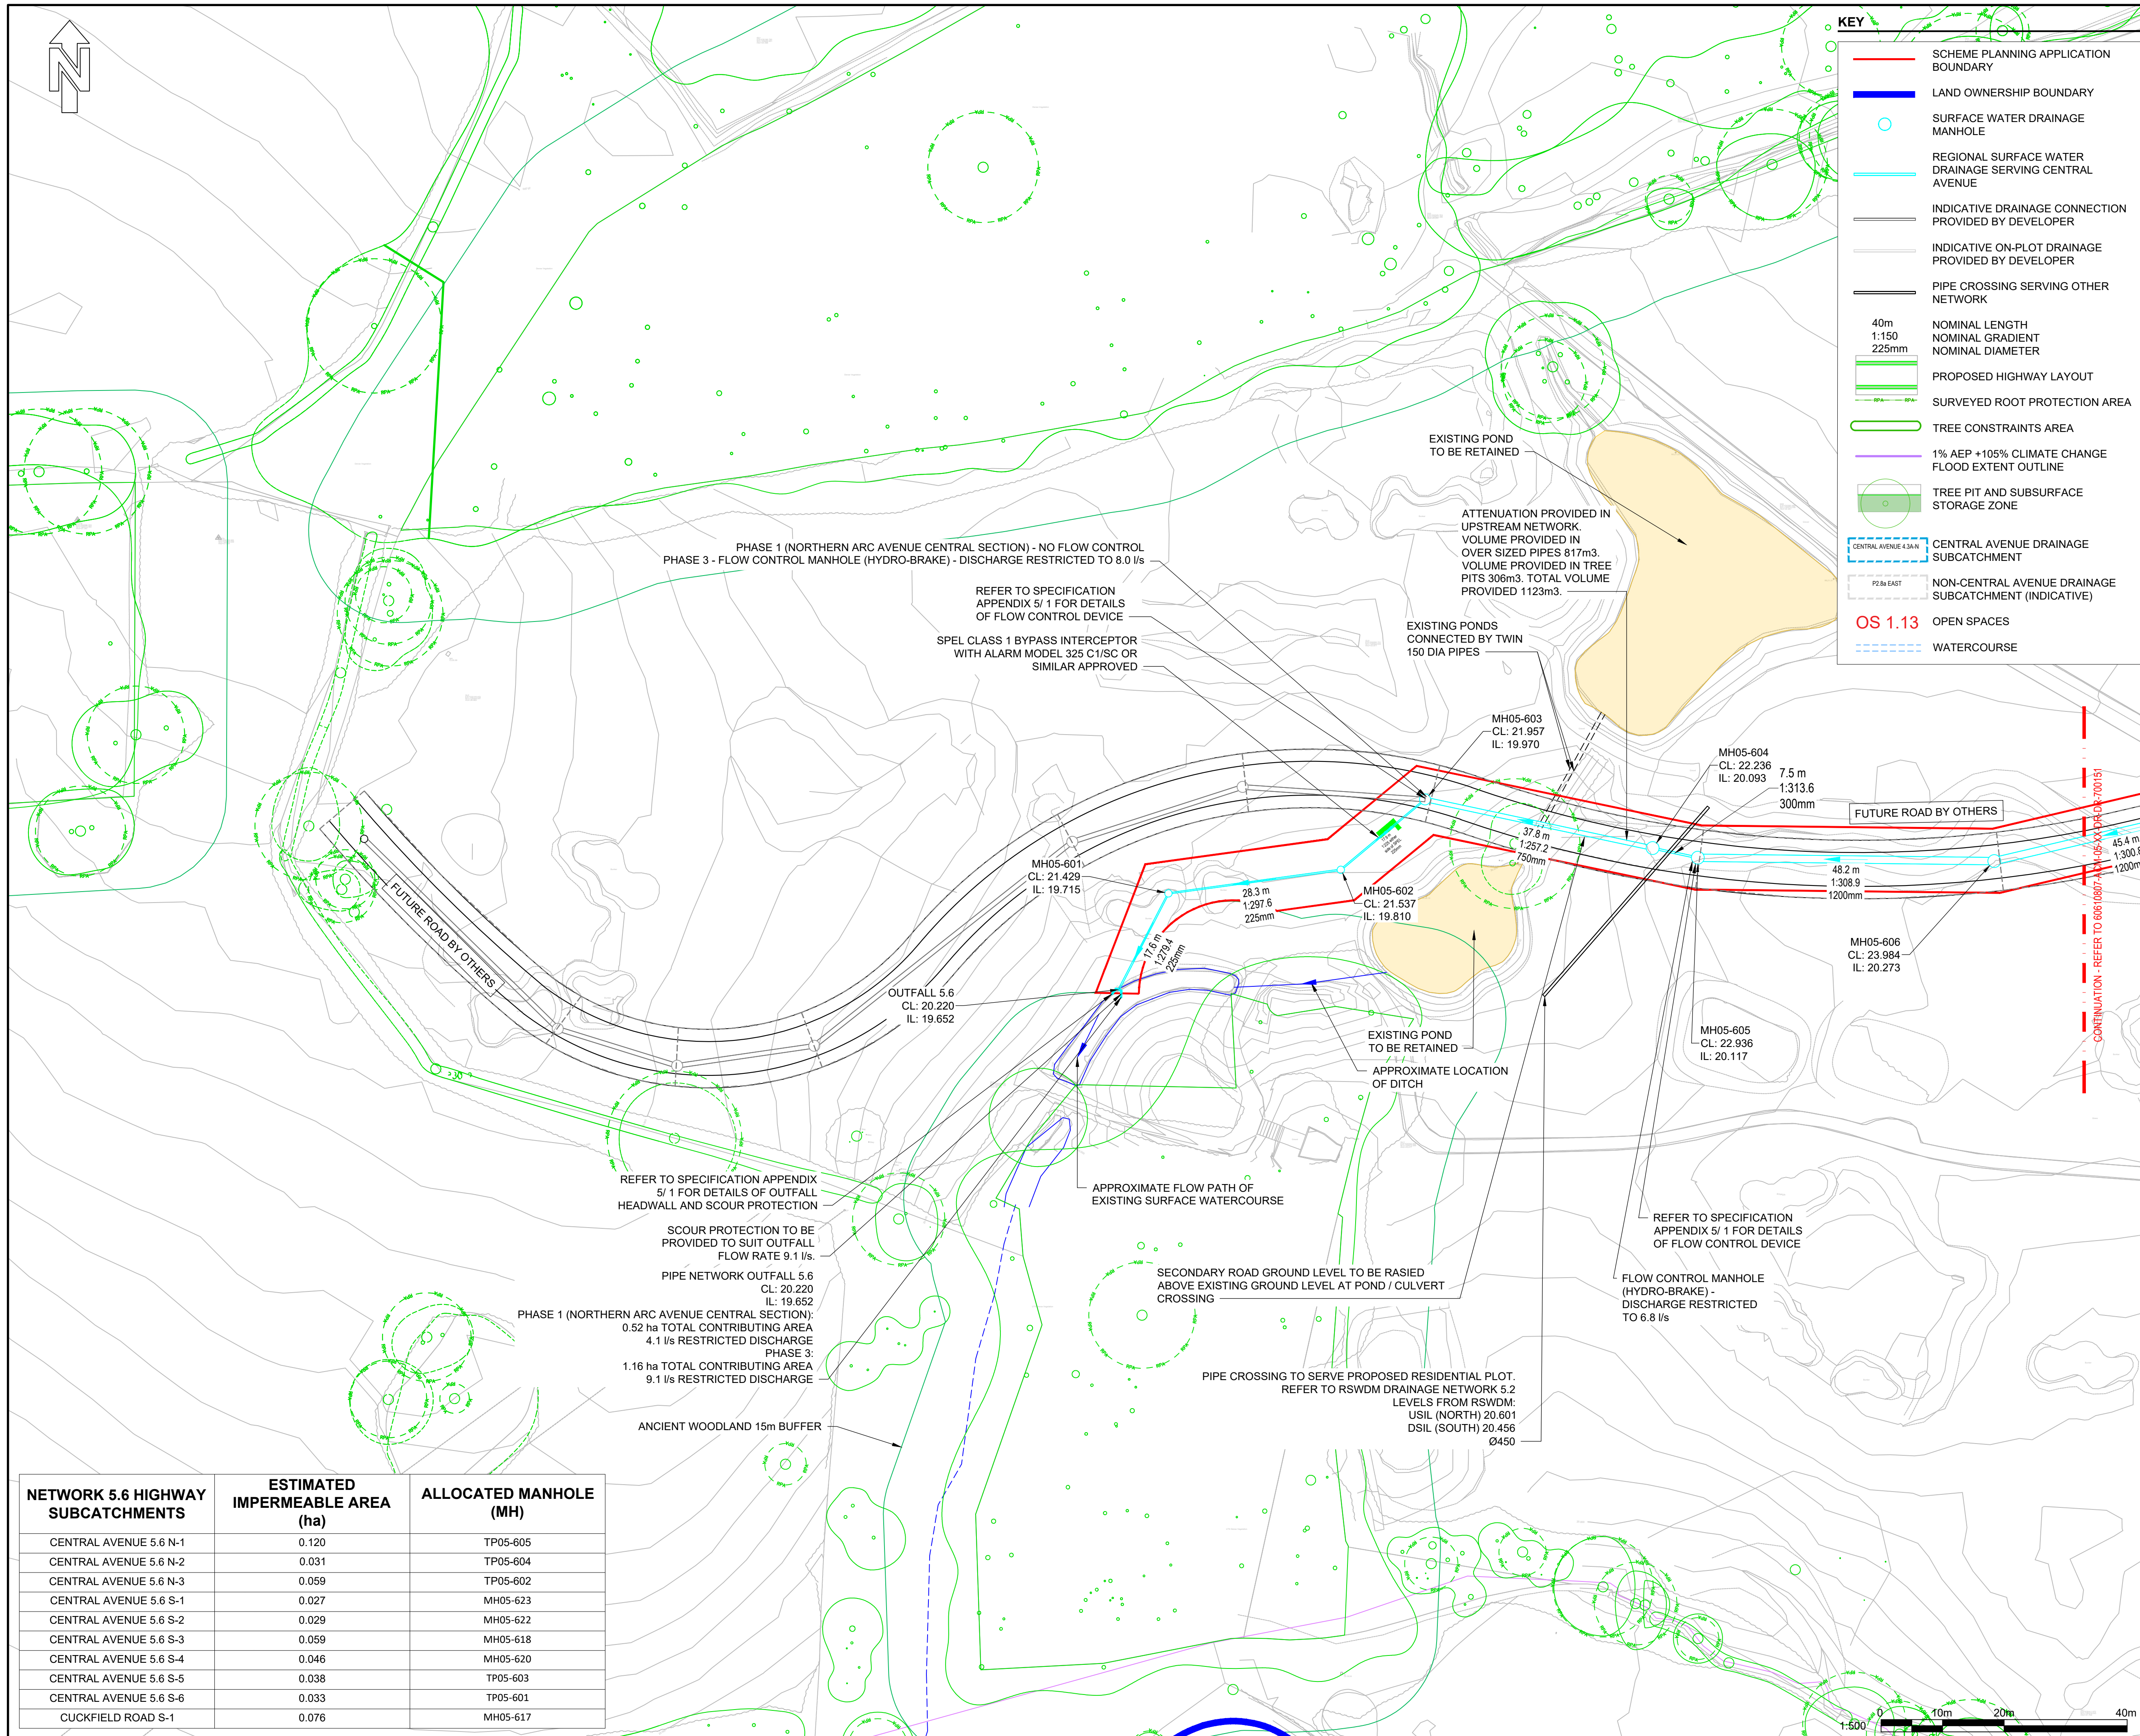

PROJECT

Brookleigh -
Northern Arc avenue
Central Section

CLIENT

Homes England

CONSULTANT

AECOM
Aldgate Tower
2 Lemn Street
London, E1 8FA
United Kingdom

T +44 (0)2076 452000
www.aecom.com

NOTES

1. Do not scale from the drawing.
2. All levels shown are in metres above ordnance datum (mAOD) unless stated otherwise.
3. Drawing is to be read in conjunction with the following:
60610807-ACM-05-XX-DR-DR-700151
60610807-ACM-05-XX-DR-DR-700152.
4. For drainage long sections refer to drawings
60610807-ACM-05-XX-DR-DR-700250
60610807-ACM-05-XX-DR-DR-700251
60610807-ACM-05-XX-DR-DR-700252
60610807-ACM-05-XX-DR-DR-700253.
For manhole schedule refer
to 60610807-ACM-05-XX-DR-DR-700550
For typical details including tree pit detail refer to
60610807-ACM-XX-XX-DR-DR-702000
to 702008.
For drainage specification refer to document
60610807-ACM-XX-XX-RP-DR-700000.
5. Contributing drainage areas have been estimated from finished topography and assigned to a manhole within the drainage model.
6. Attenuation volumes are from Microdrainage model
60610807-ACM-05-XX-CU-DR-700056.


SUITABILITY

S3 FOR REVIEW & COMMENT

ISSUE/REVISION

P04	20.12.2024	SECOND ISSUE
P03	19.01.2024	FIRST ISSUE
P02	25.08.2023	DRAFT ISSUE
P01	16.08.2022	PRELIMINARY DESIGN
I/R	DATE	DESCRIPTION

KEY PLAN

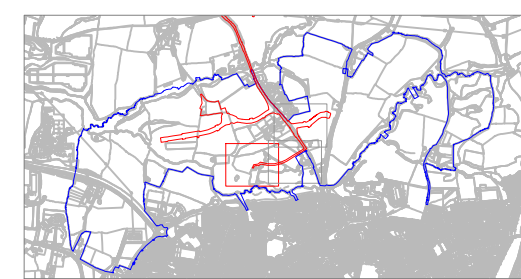

PROJECT NUMBER

60610807

SHEET TITLE

DRAINAGE AREA 05
HIGHWAY DRAINAGE LAYOUT PLAN
SHEET 1 OF 3

SHEET NUMBER

60610807-ACM-05-XX-DR-DR-700150